

A 3D architectural rendering of a modern, single-story house with a flat roof and large windows, set on a green lawn. The house features a large open-plan living and dining area, a kitchen, a bedroom, a bathroom, and a covered patio area. The design is minimalist with white walls and light-colored flooring. The house is oriented diagonally on the lawn, with a long, narrow covered patio extending from the front-left corner. The main body of the house is rectangular with a series of large windows along the right side. The interior is furnished with a dining table, kitchen units, a bed, and a bathtub. The overall aesthetic is clean and contemporary.



Not for permits, pricing or other official purposes. This document has not been completed or checked and is for general information or comment only.

A/E: FIRM PRIME: STANTEC CHEYENNE, WY	DESIGNED:	SUB SHEET NO. A901C	TITLE OF SHEET 3BR RENDERINGS 76 OF 94	DRAWING NO. 101 198433
	CADD:			PMIS/PKG NO. 326141
	TECH. REVIEW:			SHEET 77 OF 94
	LF DATE: 06/18/2026			YELLOWSTONE NATIONAL PARK

PLOT DATE: 6/12/2026 3:24:40 PM REVIT VERSION: 2025
Autodesk Docs://185706708_YELL_NPS/08_arch_185706708_3bdr.rvt

ALL RENDERINGS FOR REFERENCE ONLY



KITCHEN - DAY



KITCHEN - EVENING

**PRELIMINARY
NOT FOR
CONSTRUCTION**
Not for permits, pricing or other official
purposes. This document has not been
completed or checked and is for general
information or comment only.

A/E: FIRM PRIME: STANTEC CHEYENNE, WY	DESIGNED: JC	SUB SHEET NO. A901D	TITLE OF SHEET 3BR ABA RENDERINGS YELLOWSTONE NATIONAL PARK	DRAWING NO. 101
	CADD: BB/PS/AS			PMIS/PKG NO. 326141
	TECH. REVIEW: LF			SHEET
	DATE: 06/18/2026			78 OF 94


PLUMBING NOTES

- 1 SEE ALL GENERAL NOTES & DISCIPLINE NOTES LOCATED ON A001
2 MECHANICAL, ELECTRICAL AND PLUMBING SYSTEMS TO BE ENGINEERED BY RESIDENTIAL MODULAR BUILDING MANUFACTURER. ALL ENGINEERING SHOWN IS SCHEMATIC AND FOR REFERENCE ONLY. ALL SYSTEMS MUST MEET MANUFACTURER RECOMMENDATIONS, ALL APPLICABLE CODES AND AHJ REQUIREMENTS.

***THIS PLUMBING LAYOUT IS PROVIDED FOR REFERENCE AND COORDINATION PURPOSES ONLY. FINAL DESIGN, SIZING, AND ROUTING OF PLUMBING SYSTEMS SHALL BE COMPLETED BY MODULAR HOUSING MANUFACTURER.

BATH 01


OWNER/PURCHASER RESPONSIBILITY
DRAIN
VENT

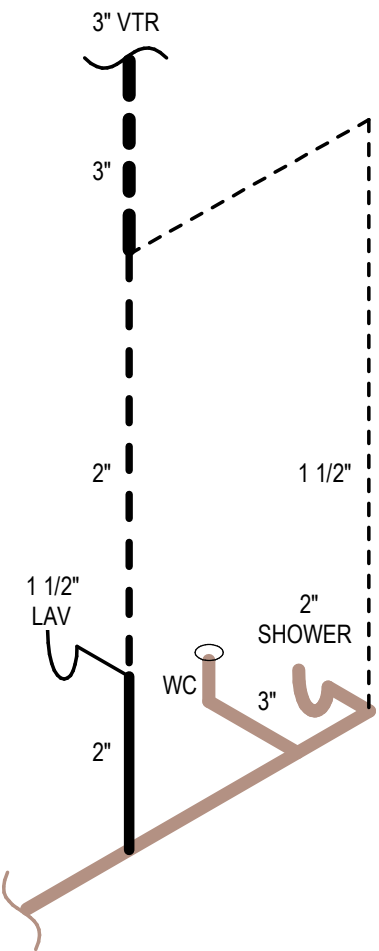


***THIS PLUMBING LAYOUT IS PROVIDED FOR REFERENCE AND COORDINATION PURPOSES ONLY. FINAL DESIGN, SIZING, AND ROUTING OF PLUMBING SYSTEMS SHALL BE COMPLETED BY MODULAR HOUSING MANUFACTURER.

BATH 02

OWNER/PURCHASER RESPONSIBILITY
DRAIN
VENT

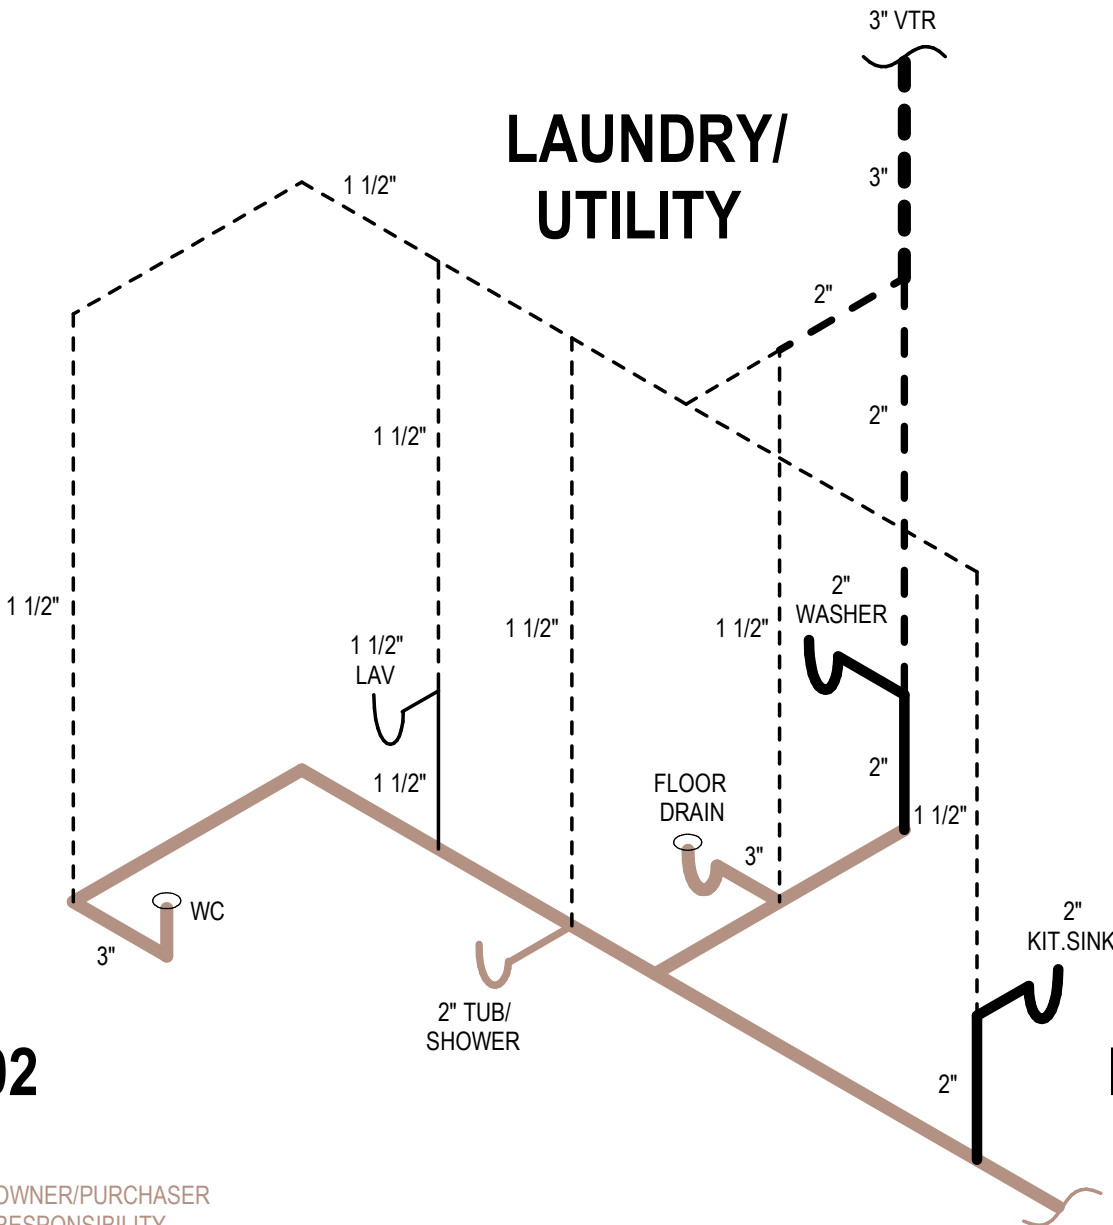

PROVIDE FREEZE-PROTECTED HOSE BIBB. LOCATION MAY VARY. COORDINATE WITH MODULAR BUILDINGS MANUFACTURER. RE: SHOP DRAWINGS.

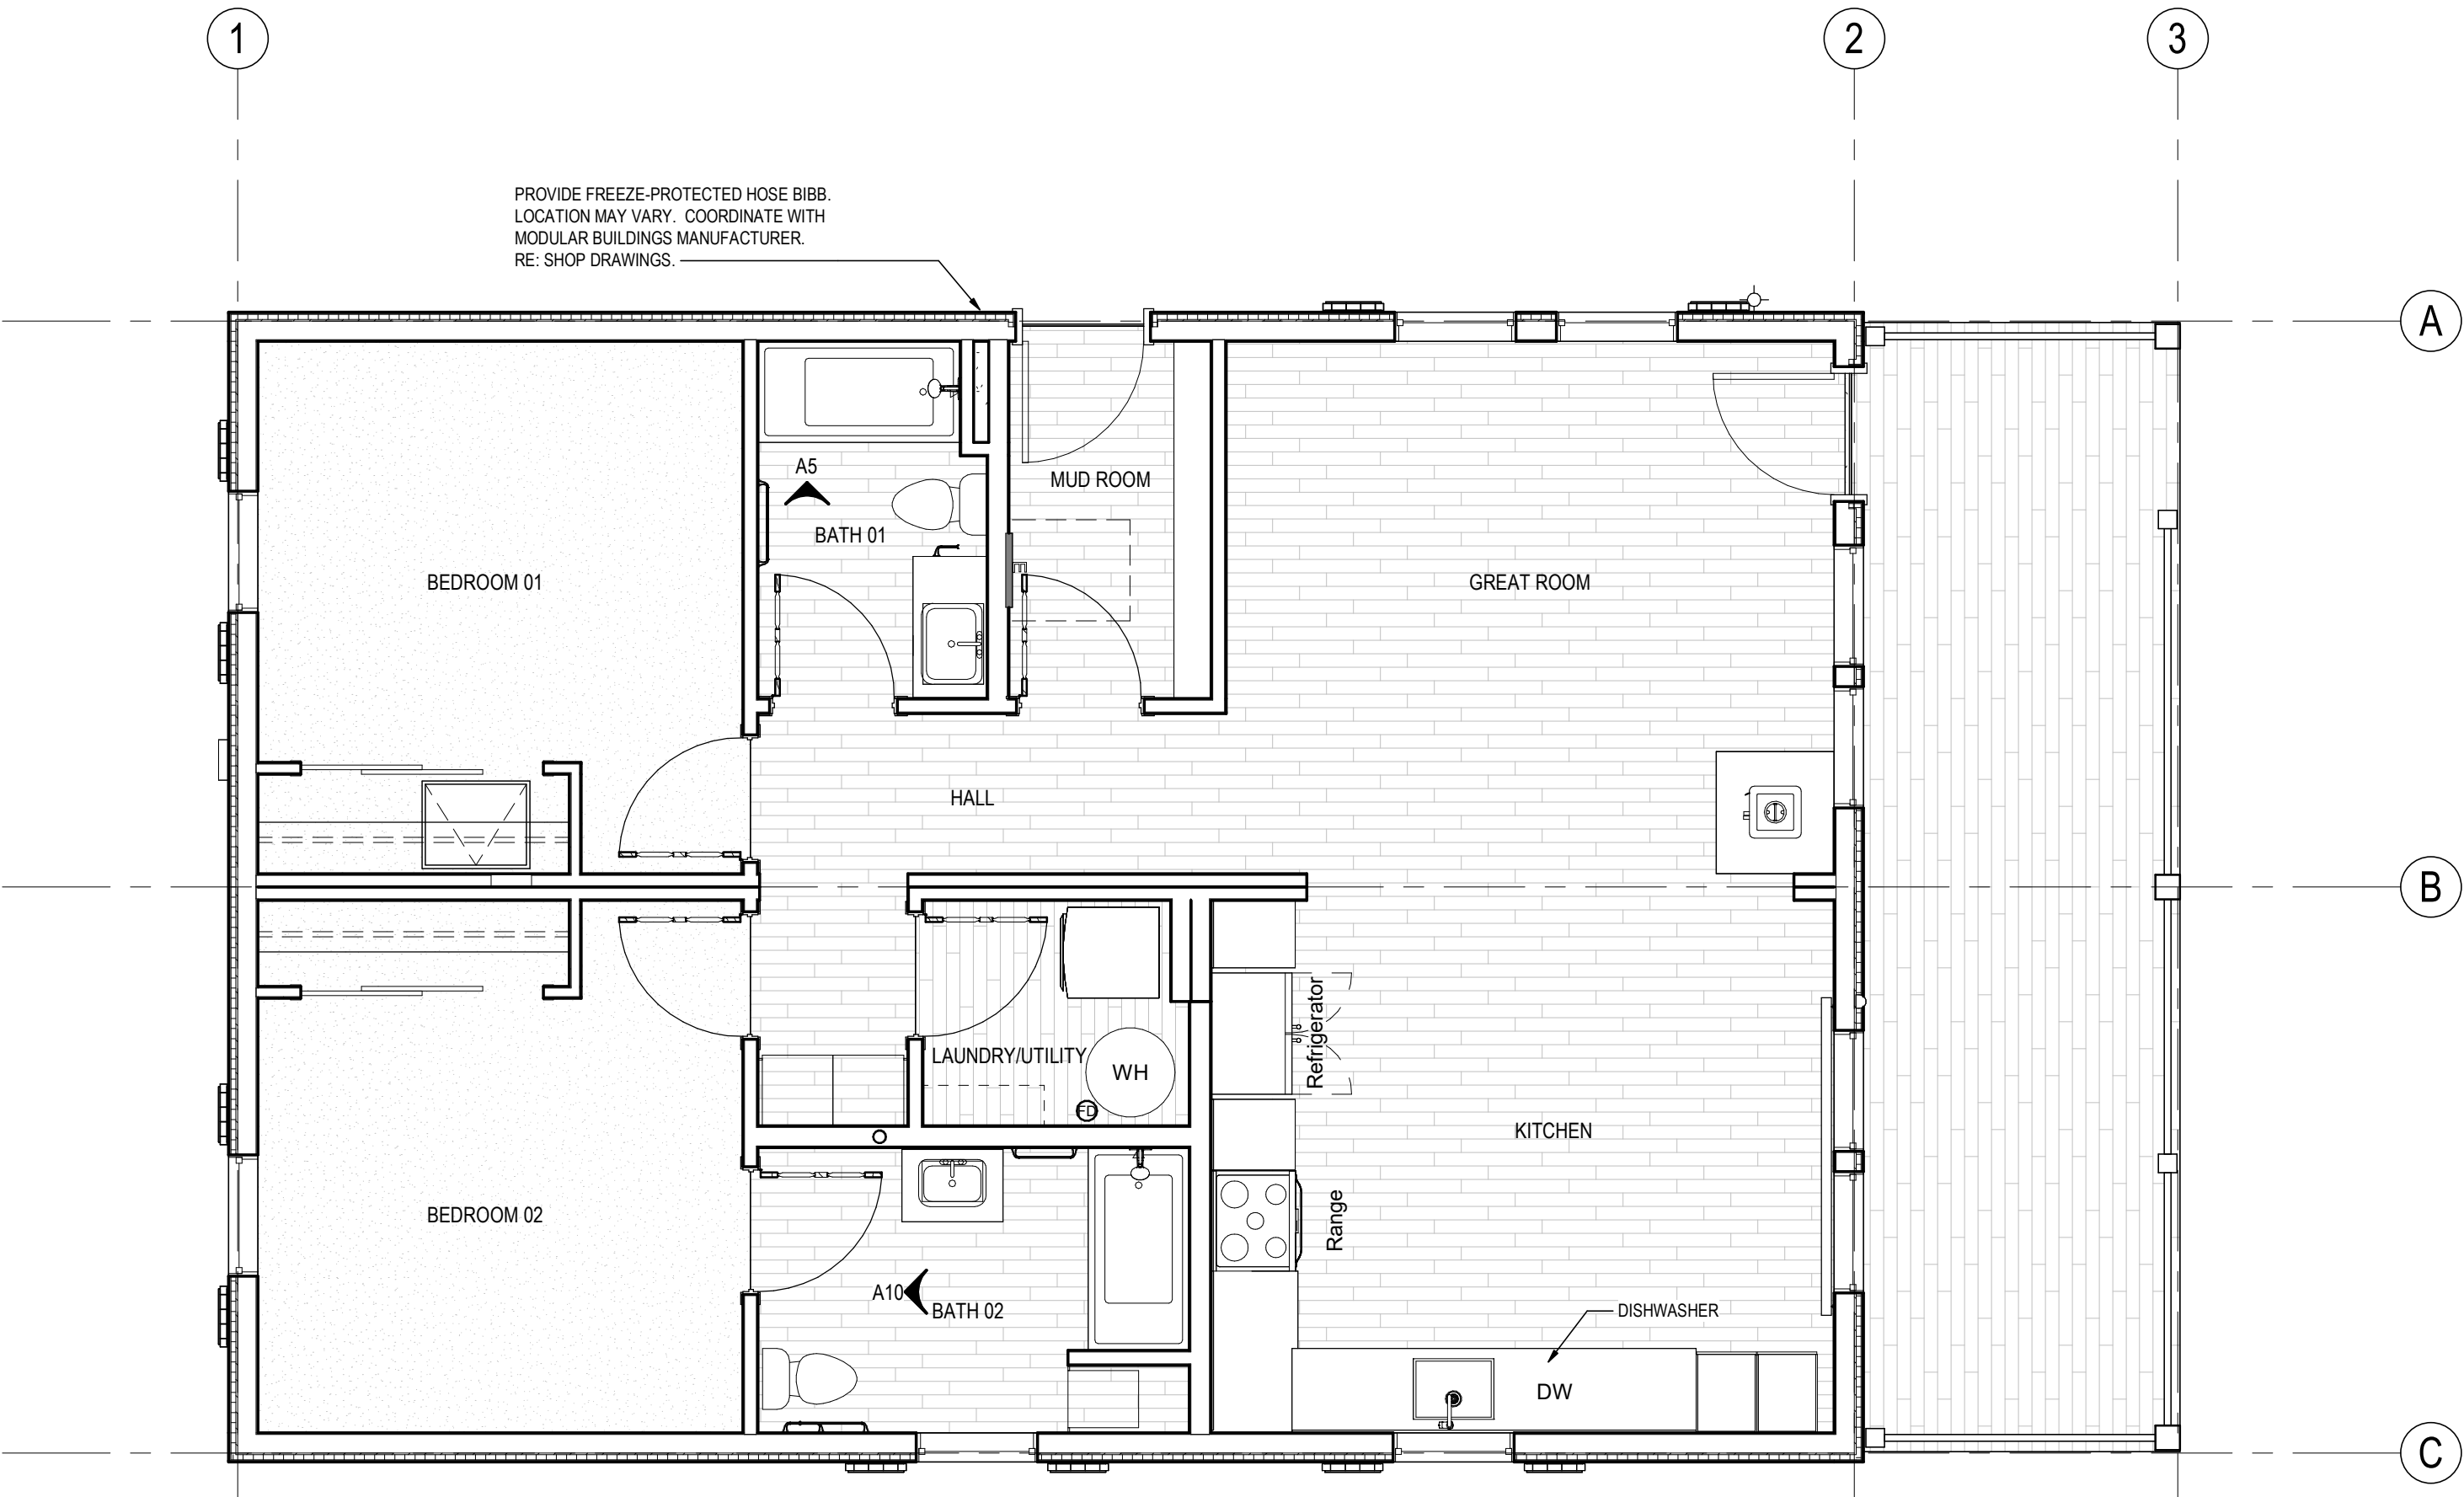

A1 LEVEL 01
P101A 1/4" = 1'-0"

PRELIMINARY
NOT FOR
CONSTRUCTION

Not for permits, pricing or other official purposes. This document has not been completed or checked and is for general information or comment only.

A/E: FIRM
PRIME:
STANTEC
CHEYENNE, WY

DESIGNED:
JC
CADD:
BB/PS/AS
TECH. REVIEW:
LF
DATE:
06/18/2026

SUB SHEET NO.
P101A

TITLE OF SHEET
2BR PLUMBING PLAN

YELLOWSTONE NATIONAL PARK

DRAWING NO.
101
198433
PMIS/PKG NO.
326141
SHEET
79 OF **94**

PL0101B 4/17/2024 3:00:07 PM - RPT111650N 202
Autodesk Docs/1857020108_VEL_MIS/568_dcm1_18570208_2024_0001.rvt


C

B

A

BATH 02 ABA

OWNER/PURCHASER
RESPONSIBILITY
DRAIN
VENT

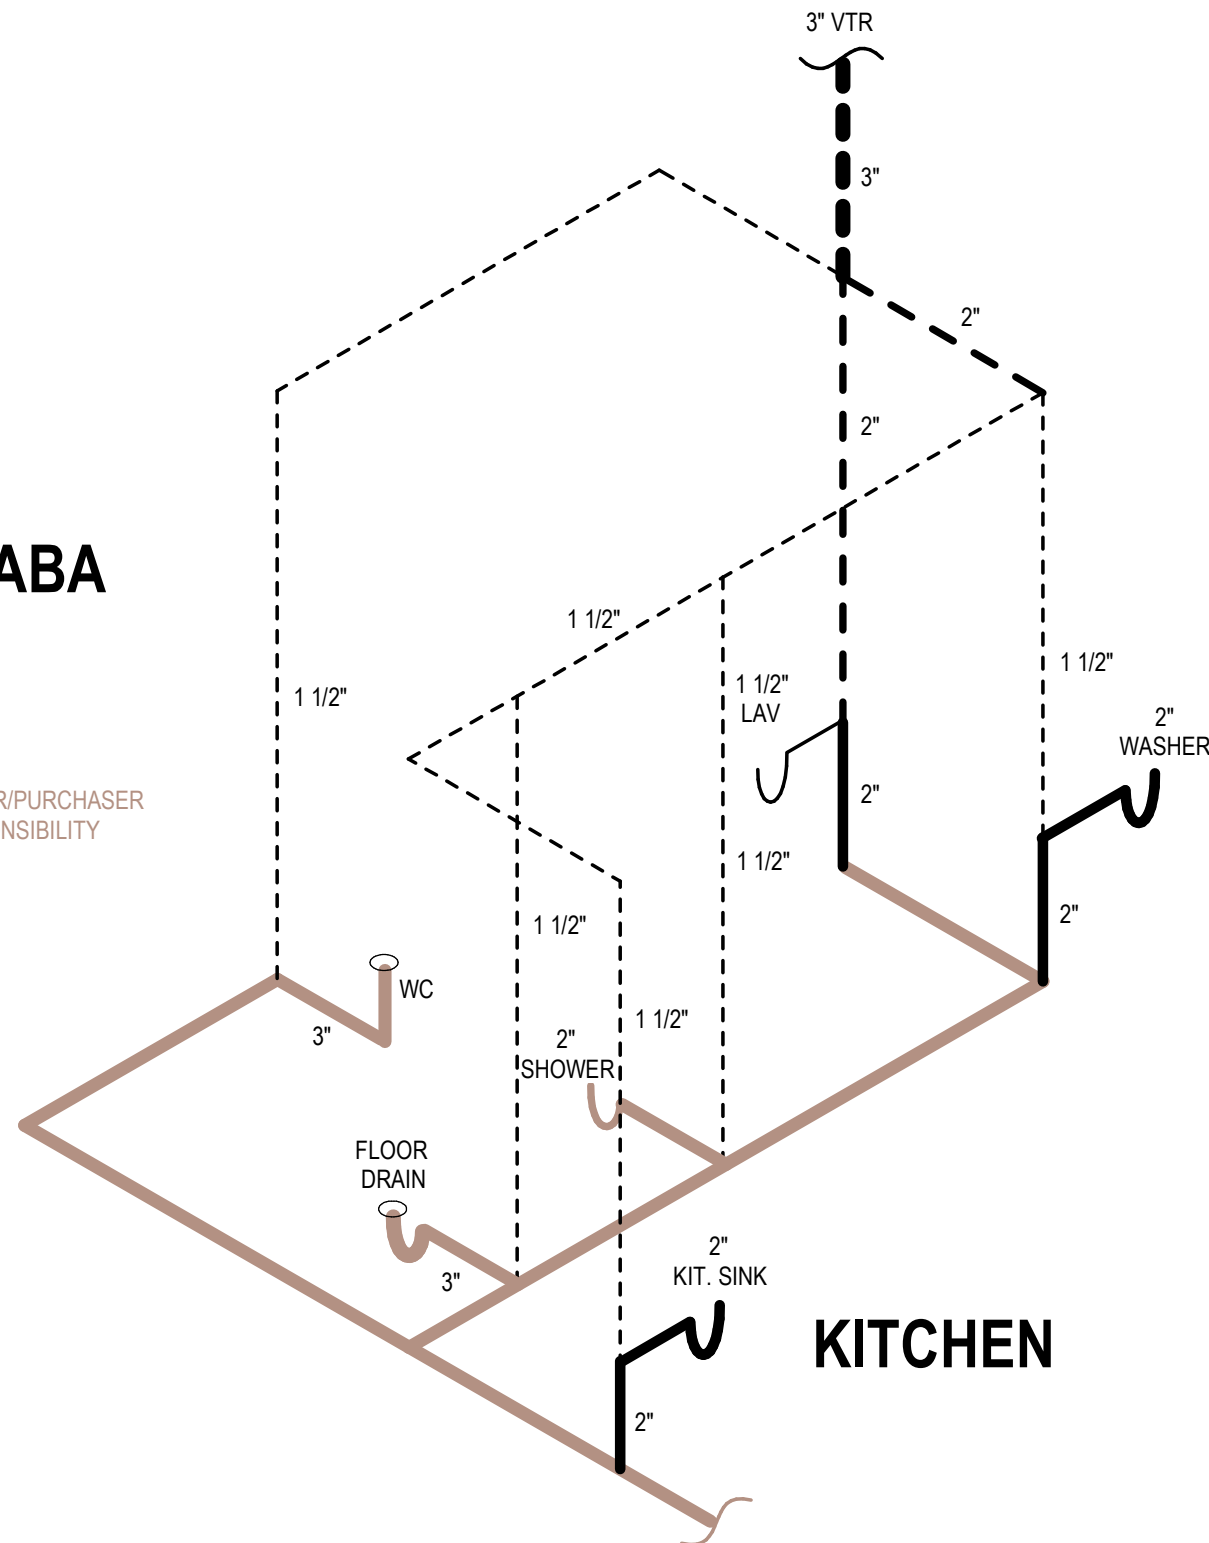


***THIS PLUMBING LAYOUT IS PROVIDED FOR REFERENCE AND COORDINATION PURPOSES ONLY.
FINAL DESIGN, SIZING, AND ROUTING OF PLUMBING SYSTEMS SHALL BE COMPLETED BY
MODULAR HOUSING MANUFACTURER.

***THIS PLUMBING LAYOUT IS PROVIDED FOR REFERENCE AND COORDINATION PURPOSES ONLY.
FINAL DESIGN, SIZING, AND ROUTING OF PLUMBING SYSTEMS SHALL BE COMPLETED BY
MODULAR HOUSING MANUFACTURER.

BATH 01

OWNER/PURCHASER
RESPONSIBILITY
DRAIN
VENT

PROVIDE ACCESSIBLE FREEZE-PROTECTED HOSE BIBB.
LOCATION MAY VARY. COORDINATE WITH MODULAR
BUILDINGS MANUFACTURER. RE: SHOP DRAWINGS.

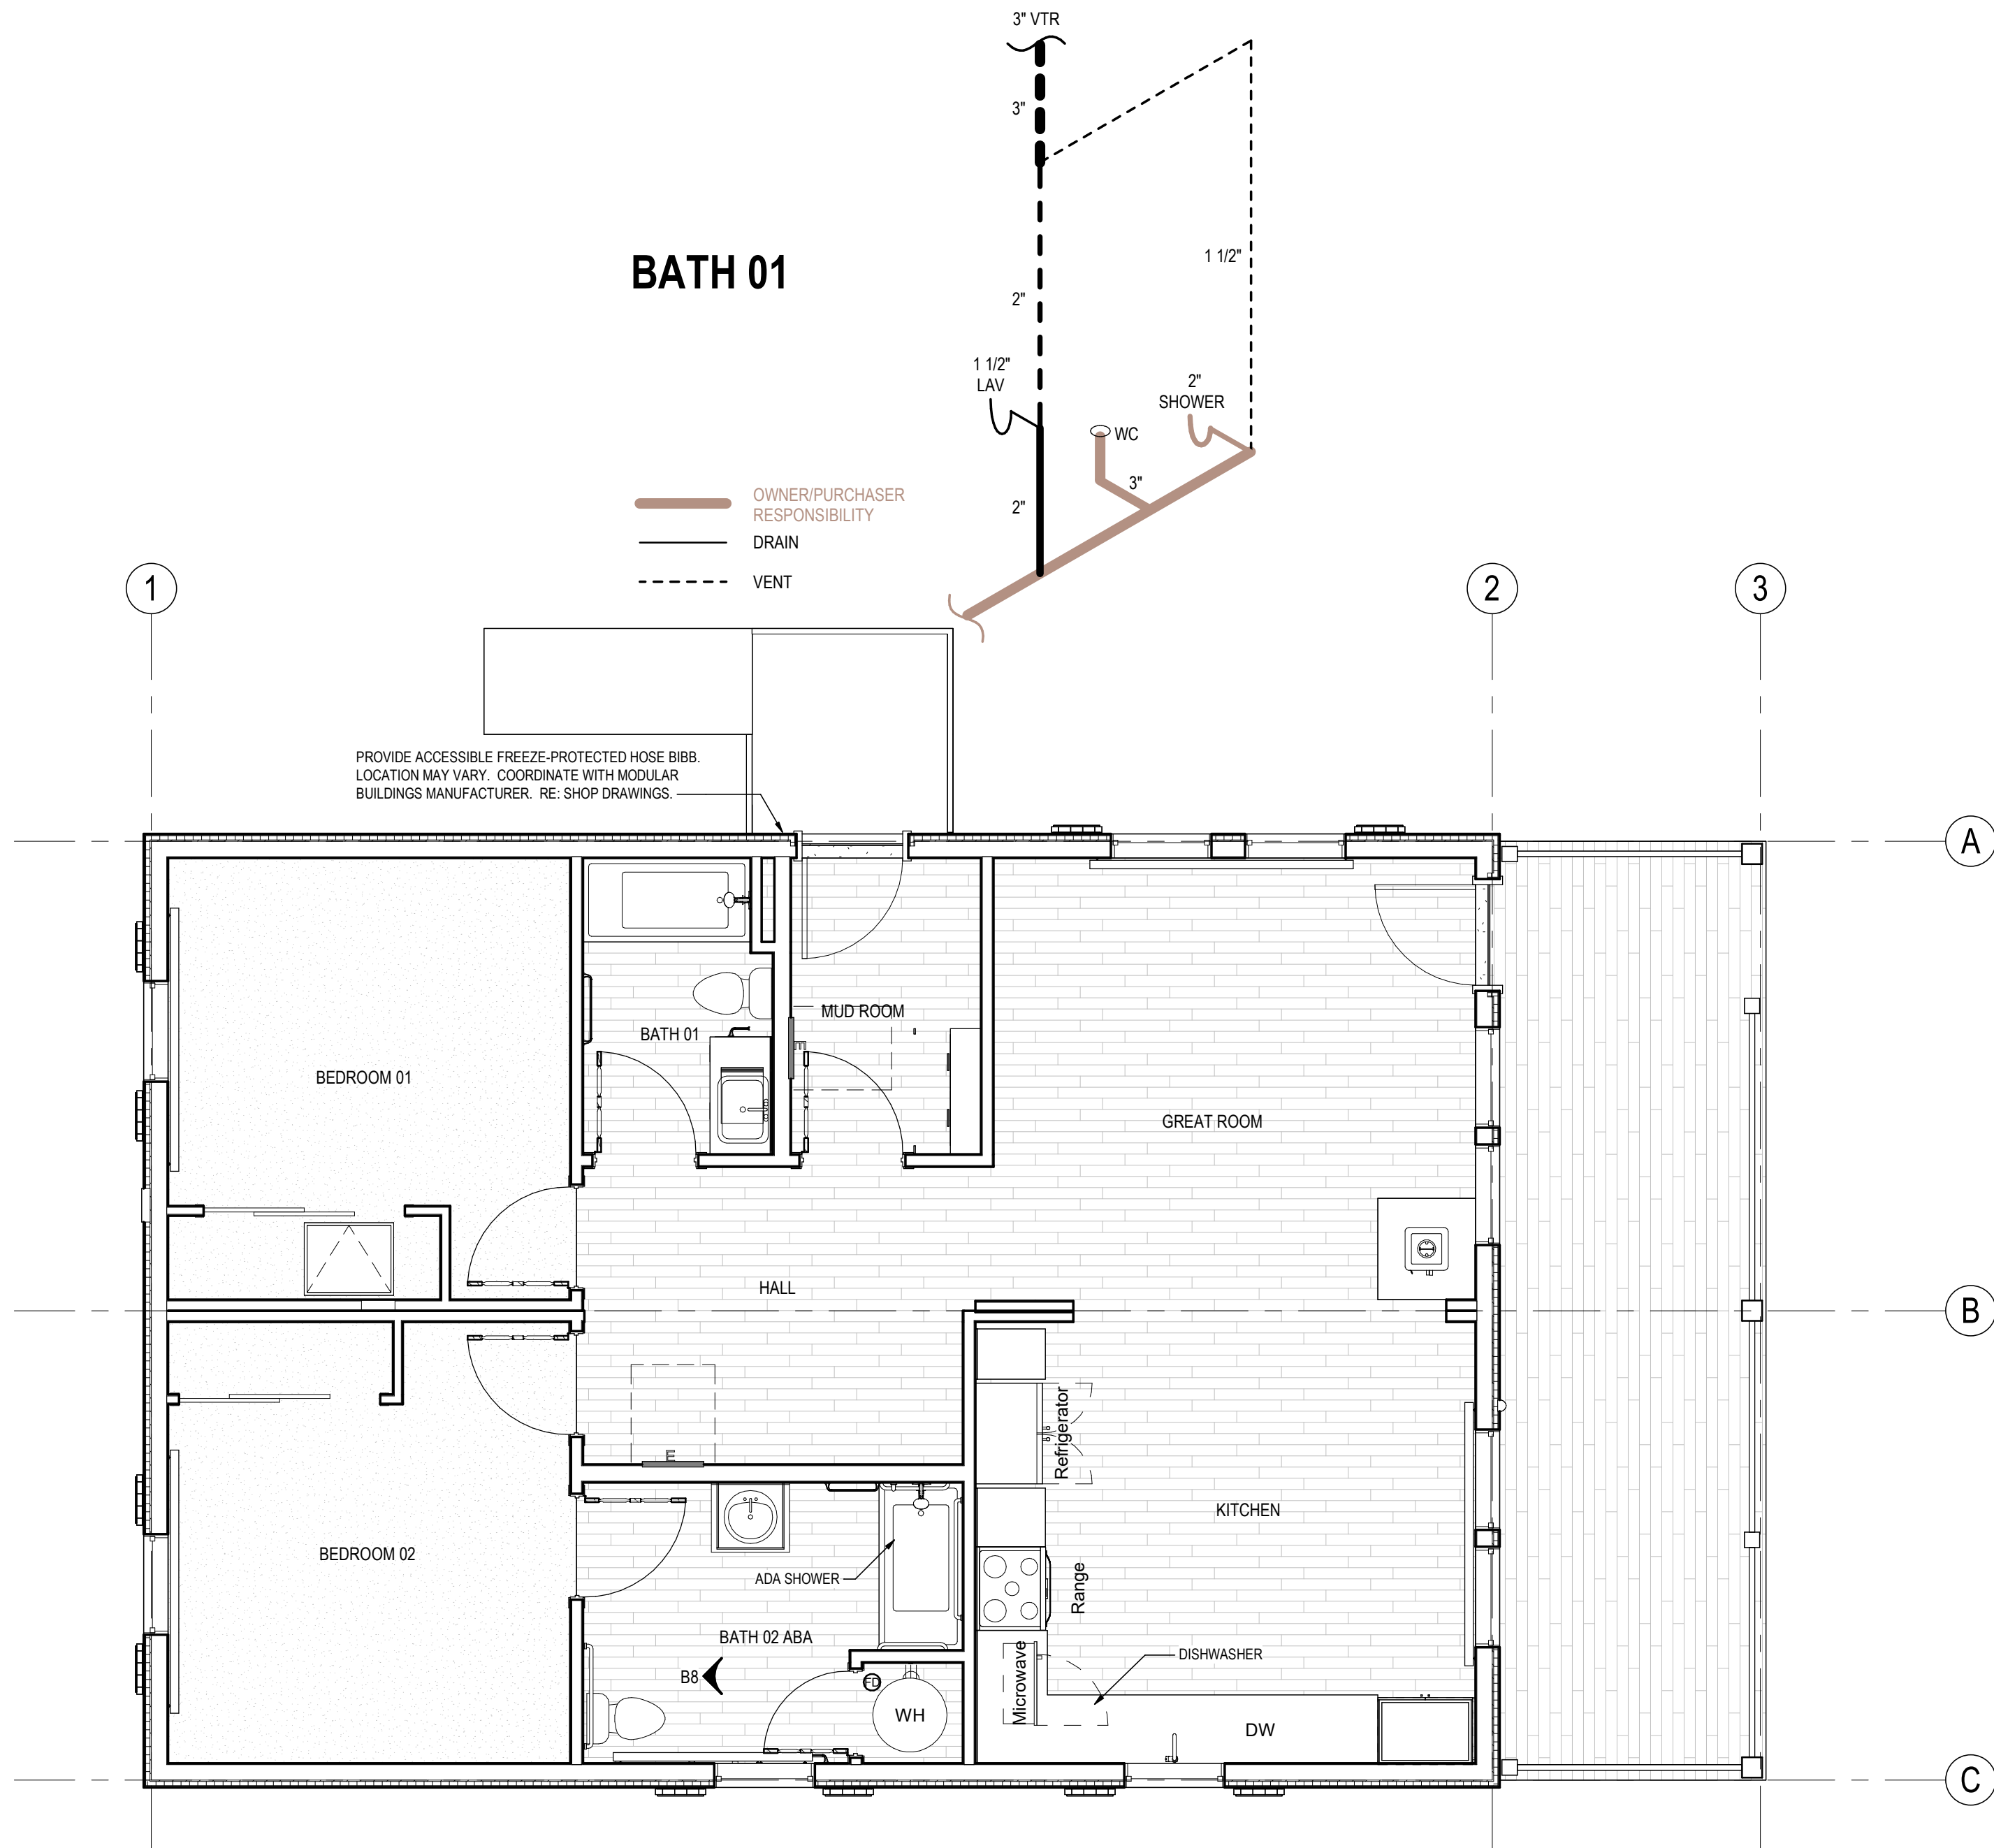

A1 LEVEL 1
P101B 1/4" = 1'-0"

PLUMBING NOTES

- 1 SEE ALL GENERAL NOTES & DISCIPLINE NOTES LOCATED ON A001
- 2 MECHANICAL, ELECTRICAL AND PLUMBING SYSTEMS TO BE ENGINEERED BY RESIDENTIAL MODULAR BUILDING MANUFACTURER. ALL ENGINEERING SHOWN IS SCHEMATIC AND FOR REFERENCE ONLY. ALL SYSTEMS MUST MEET MANUFACTURER RECOMMENDATIONS, ALL APPLICABLE CODES AND AHJ REQUIREMENTS.

PRELIMINARY NOT FOR CONSTRUCTION

Not for permits, pricing or other official
purposes. This document has not been
completed or checked and is for general
information or comment only.

A/E: FIRM
PRIME:
STANTEC
CHEYENNE, WY

DESIGNED:
JC
CADD:
BB/PS/AS
TECH. REVIEW:
LF
DATE:
06/18/2026

SUB SHEET NO.
P101B

TITLE OF SHEET
2BR ABA PLUMBING PLAN

YELLOWSTONE NATIONAL PARK

DRAWING NO.
101
198433
PMIS/PKG NO.
326141A/326104
SHEET
80 OF **94**

PLG DATE: 4/17/2024 3:44:40 PM, RUN DATE: 05/01/2024
ANSWER: D:\2024\18570708\TEL\18570708.dwg, 18570708.dwg

A

B

C

***THIS PLUMBING LAYOUT IS PROVIDED FOR REFERENCE AND COORDINATION PURPOSES ONLY.
FINAL DESIGN, SIZING, AND ROUTING OF PLUMBING SYSTEMS SHALL BE COMPLETED BY
MODULAR HOUSING MANUFACTURER.


***THIS PLUMBING LAYOUT IS PROVIDED FOR REFERENCE AND COORDINATION PURPOSES ONLY.
FINAL DESIGN, SIZING, AND ROUTING OF PLUMBING SYSTEMS SHALL BE COMPLETED BY
MODULAR HOUSING MANUFACTURER.

PLUMBING NOTES

- 1 SEE ALL GENERAL NOTES & DISCIPLINE NOTES LOCATED ON A001
- 2 MECHANICAL, ELECTRICAL AND PLUMBING SYSTEMS TO BE ENGINEERED BY RESIDENTIAL MODULAR BUILDING MANUFACTURER. ALL ENGINEERING SHOWN IS SCHEMATIC AND FOR REFERENCE ONLY. ALL SYSTEMS MUST MEET MANUFACTURER RECOMMENDATIONS AND ALL APPLICABLE CODES AND AHJ REQUIREMENTS.

LAUNDRY

OWNER/PURCHASER
RESPONSIBILITY
DRAIN
VENT

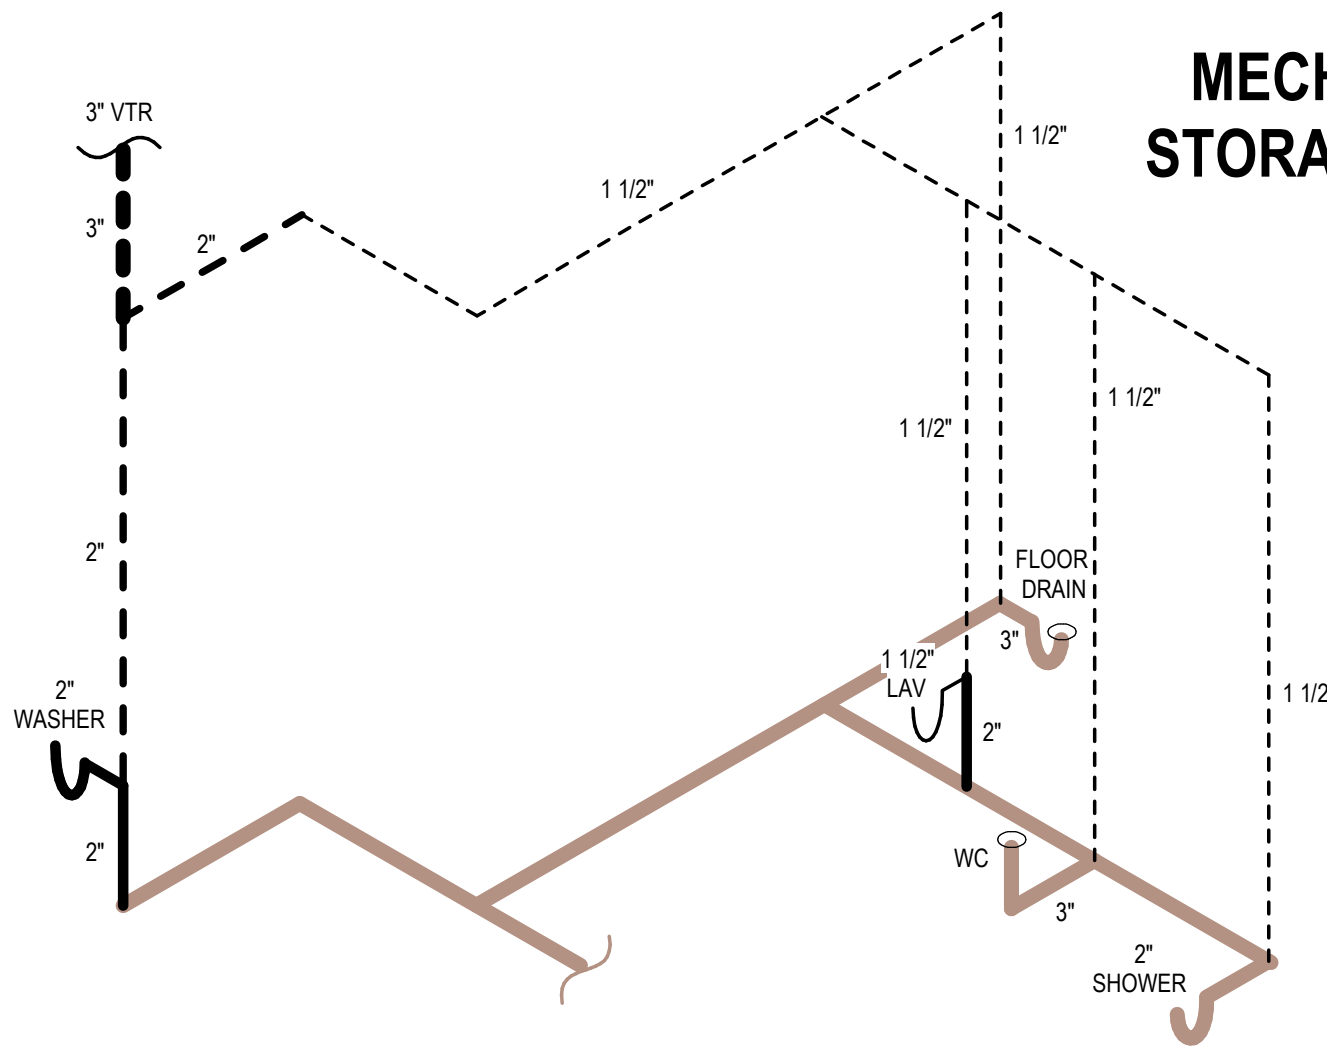


BATH 02


MECH/
STORAGE

KITCHEN

OWNER/PURCHASER
RESPONSIBILITY
DRAIN
VENT

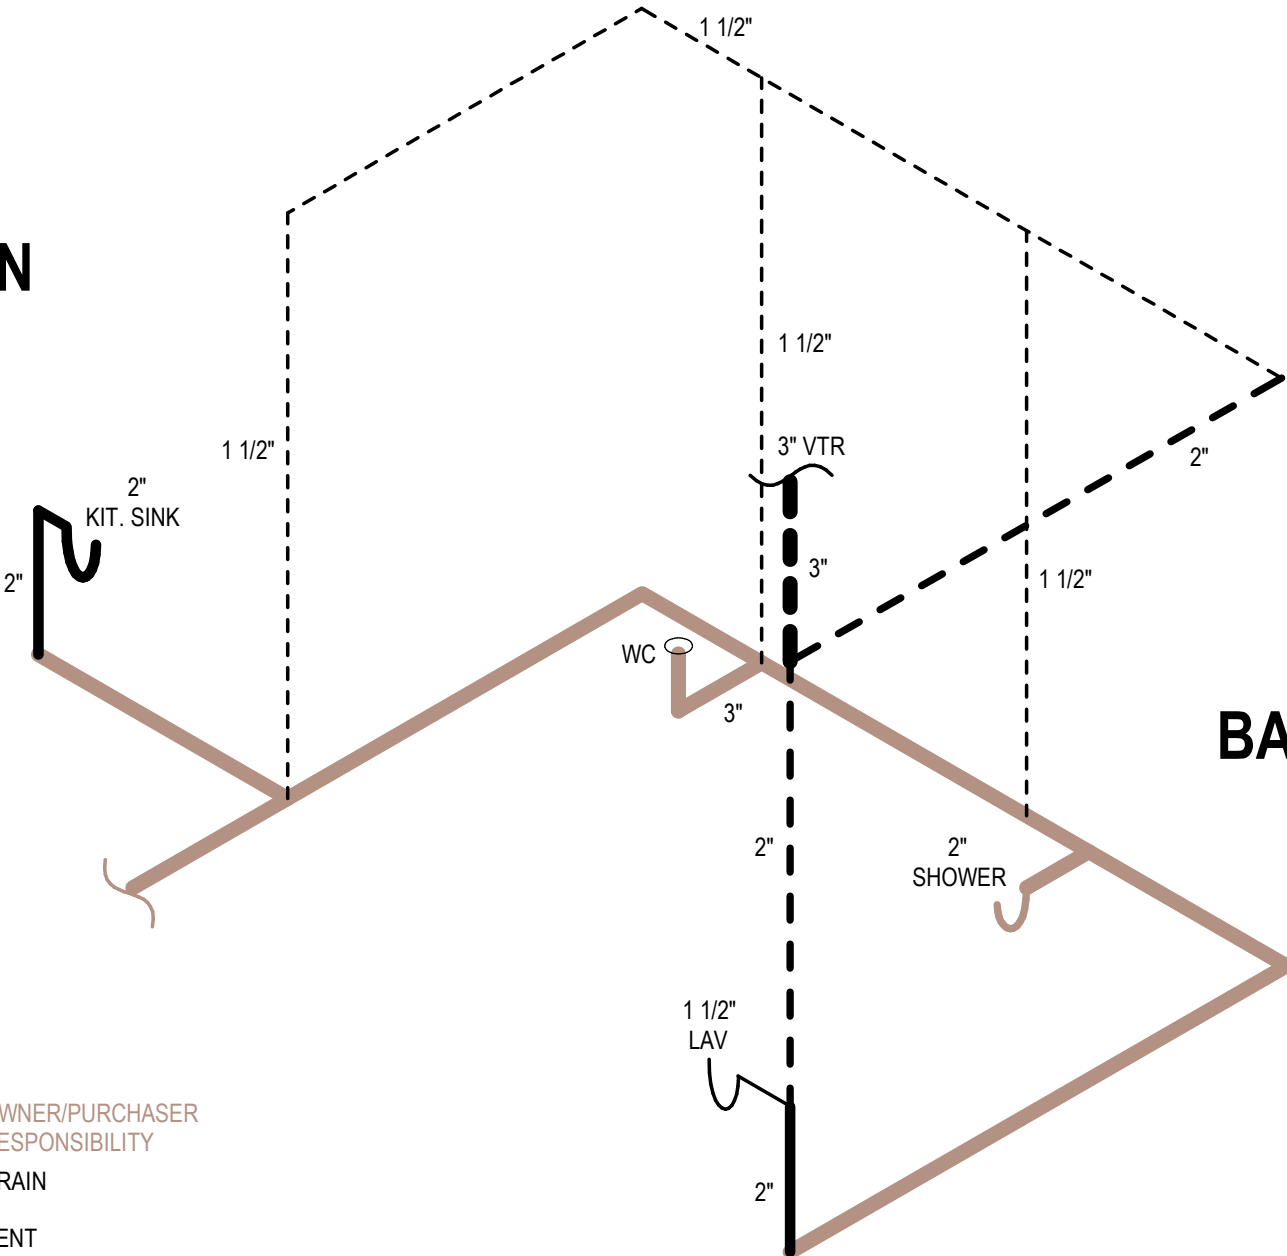

BATH 01

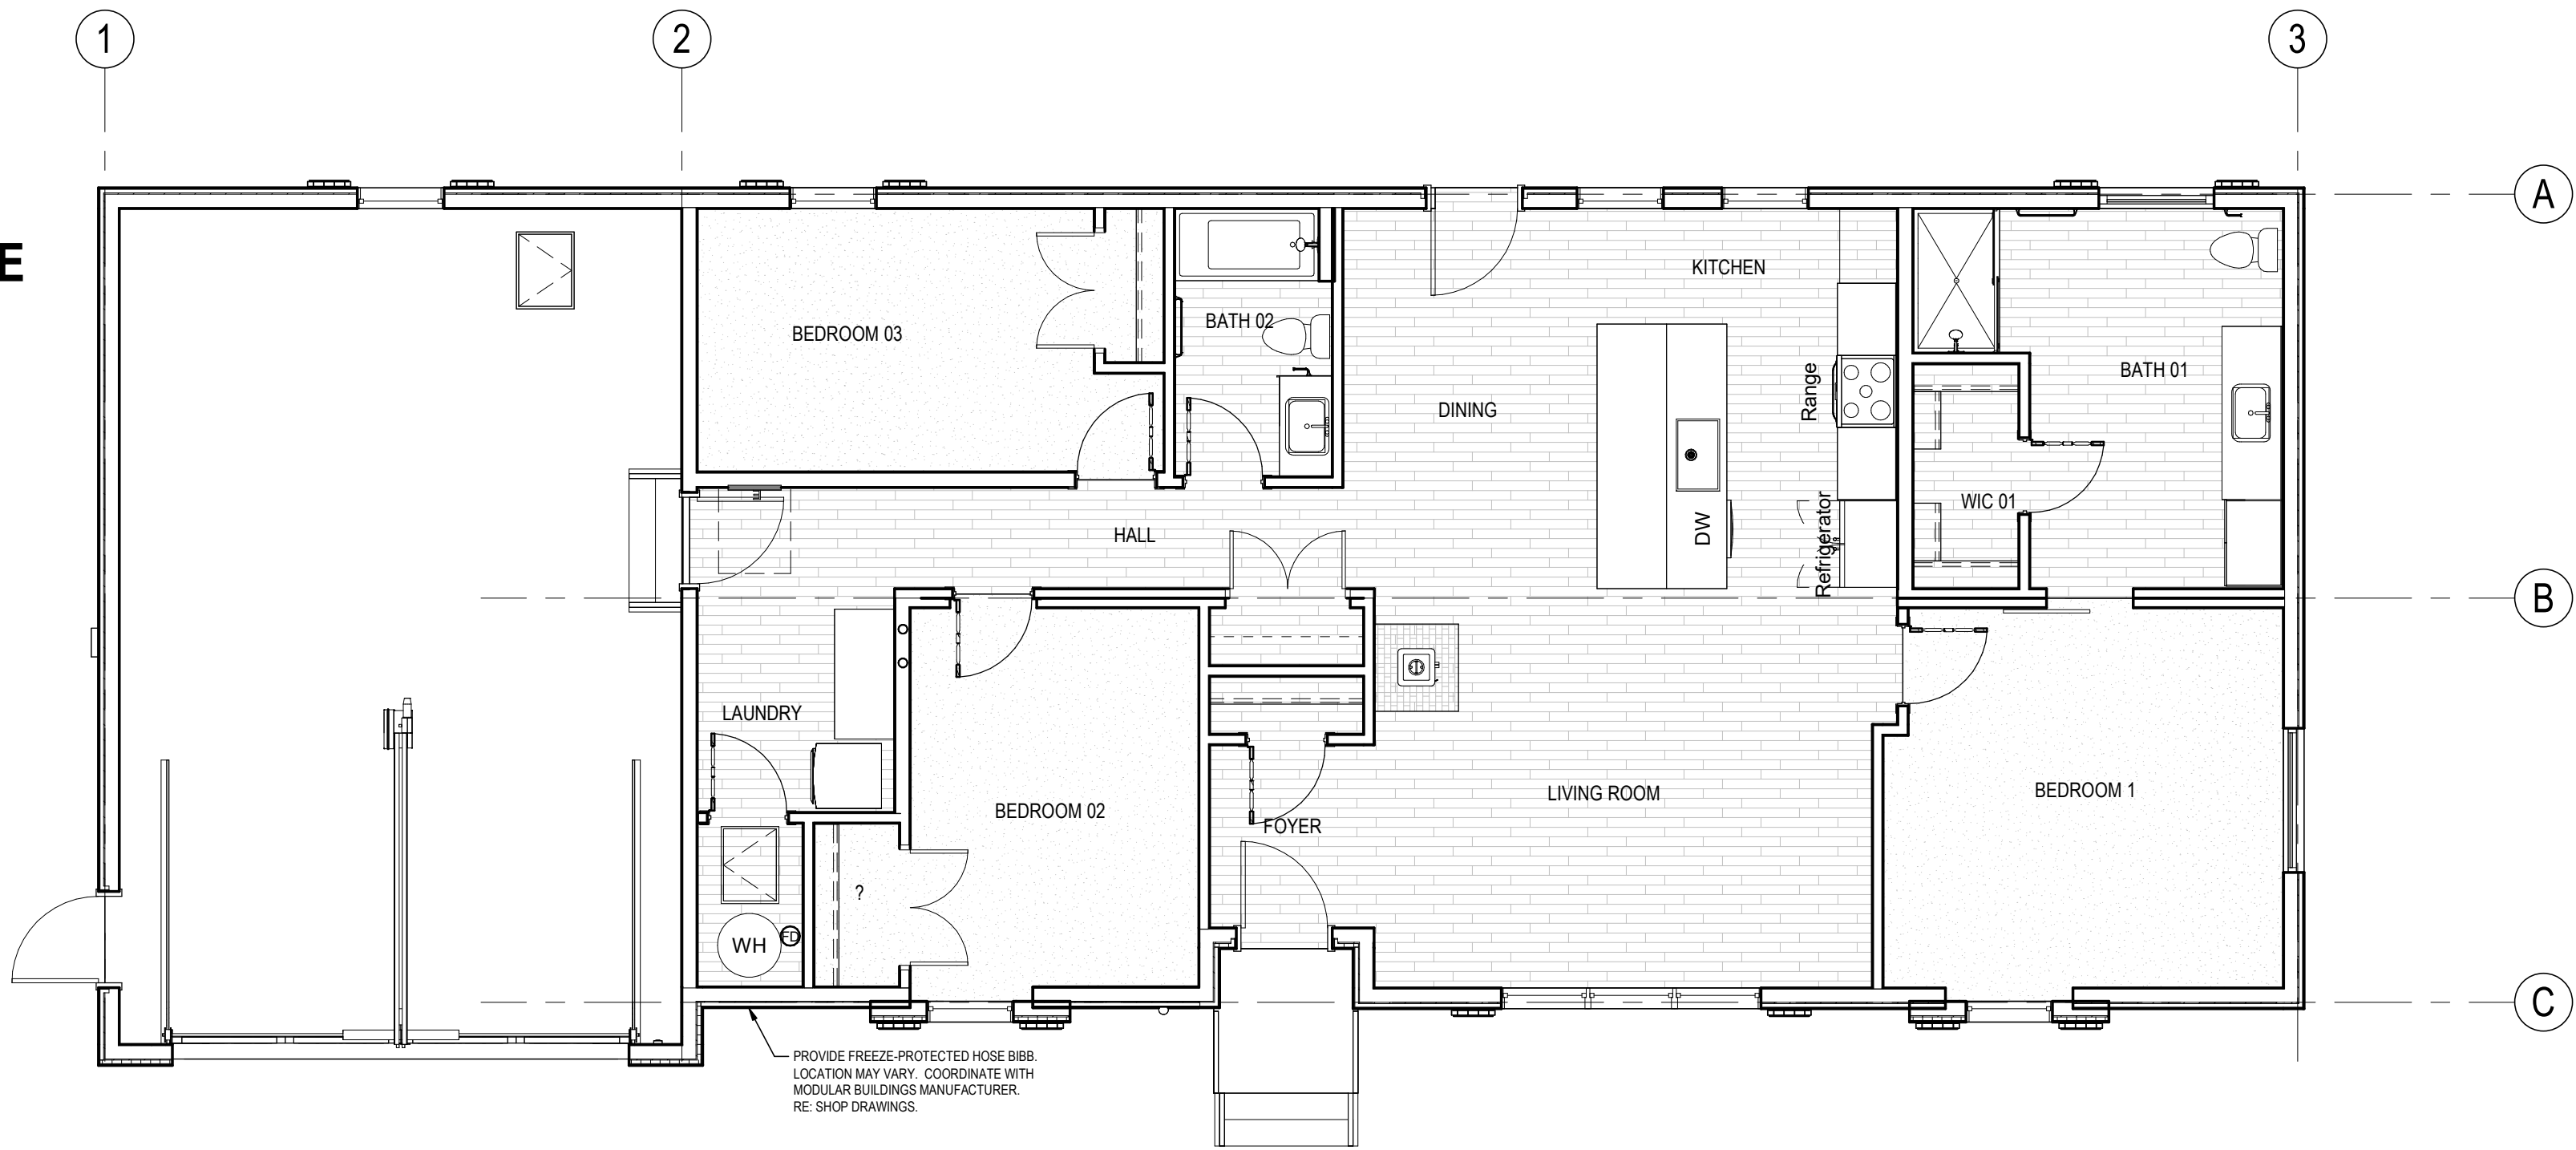

1A
P101C

LEVEL 01 PLUMBING PLAN

3/16" = 1'-0"

PRELIMINARY
NOT FOR
CONSTRUCTION

Not for permits, pricing or other official
purposes. This document has not been
completed or checked and is for general
information or comment only.

A/E: FIRM
PRIME:
STANTEC
CHEYENNE, WY

DESIGNED:
JC
CADD:
BB/PS/AS
TECH. REVIEW:
LF
DATE:
06/18/2026

SUB SHEET NO.

P101C

TITLE OF SHEET
3BR PLUMBING PLAN

YELLOWSTONE NATIONAL PARK

DRAWING NO.
101
198433
PMIS/PKG NO.
326141
SHEET
81 OF **94**

PL0101D 4/17/2024 3:54:45 PM - RPT11687ON 202
Autodesk Docs/185702708_VEL_MPS/26_sch1_185702708_Sch1_000.rvt

C


B

A

***THIS PLUMBING LAYOUT IS PROVIDED FOR REFERENCE AND COORDINATION PURPOSES ONLY.
FINAL DESIGN, SIZING, AND ROUTING OF PLUMBING SYSTEMS SHALL BE COMPLETED BY
MODULAR HOUSING MANUFACTURER.


LAUNDRY

OWNER/PURCHASER
RESPONSIBILITY
DRAIN
VENT

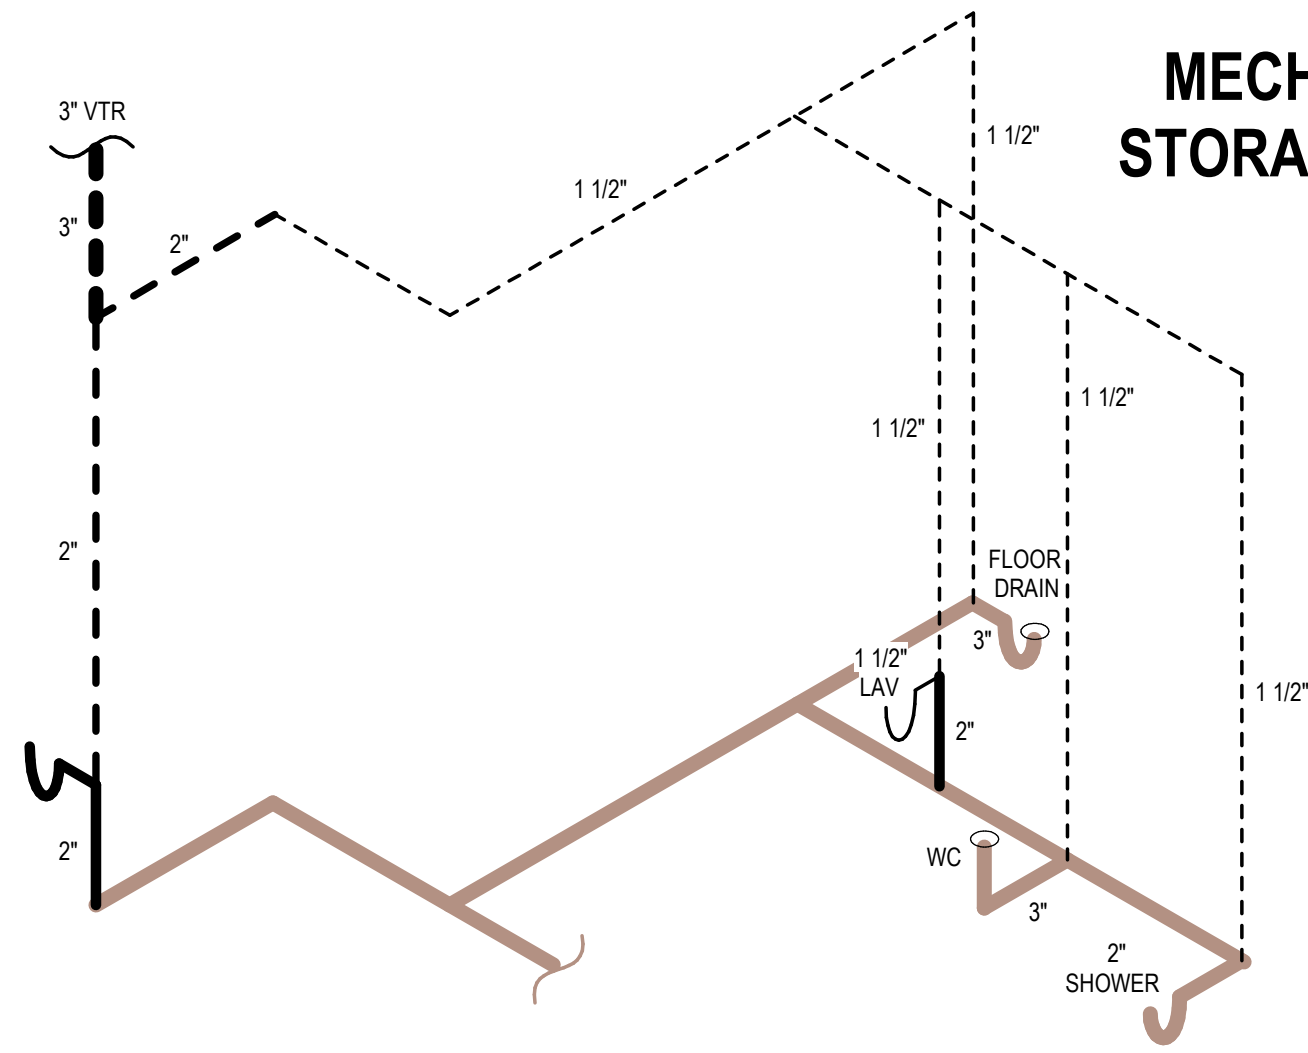

BATH 02


MECH/ STORAGE

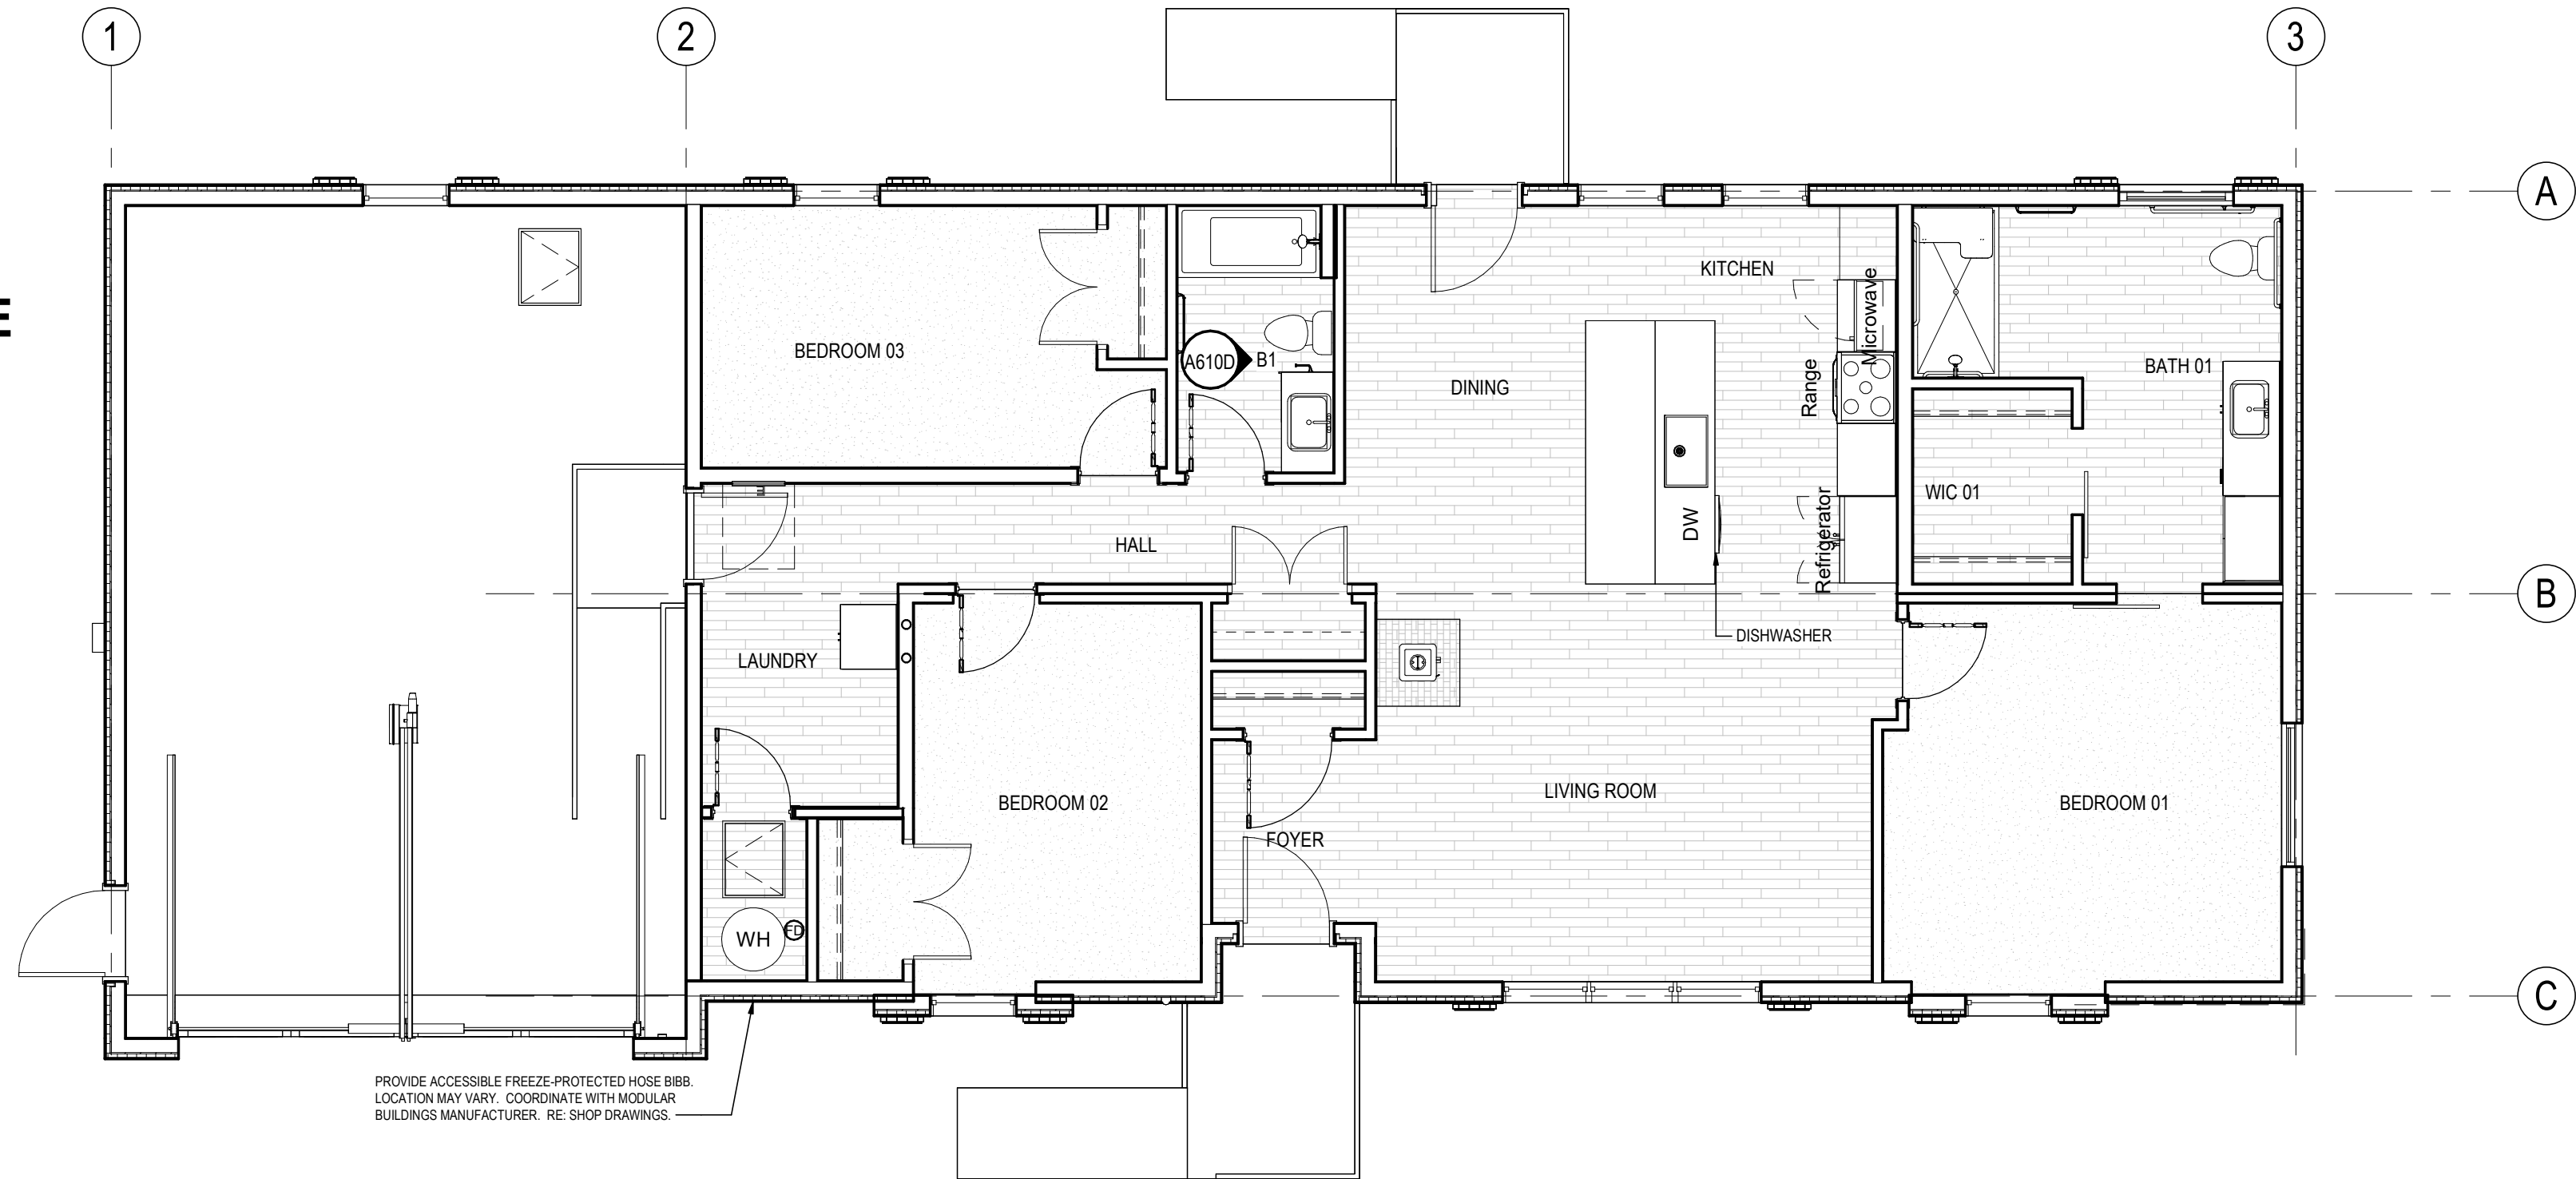

A1 LEVEL 1 - PLUMBING PLAN
P101D 3/16" = 1'-0"

KITCHEN

OWNER/PURCHASER
RESPONSIBILITY
DRAIN
VENT

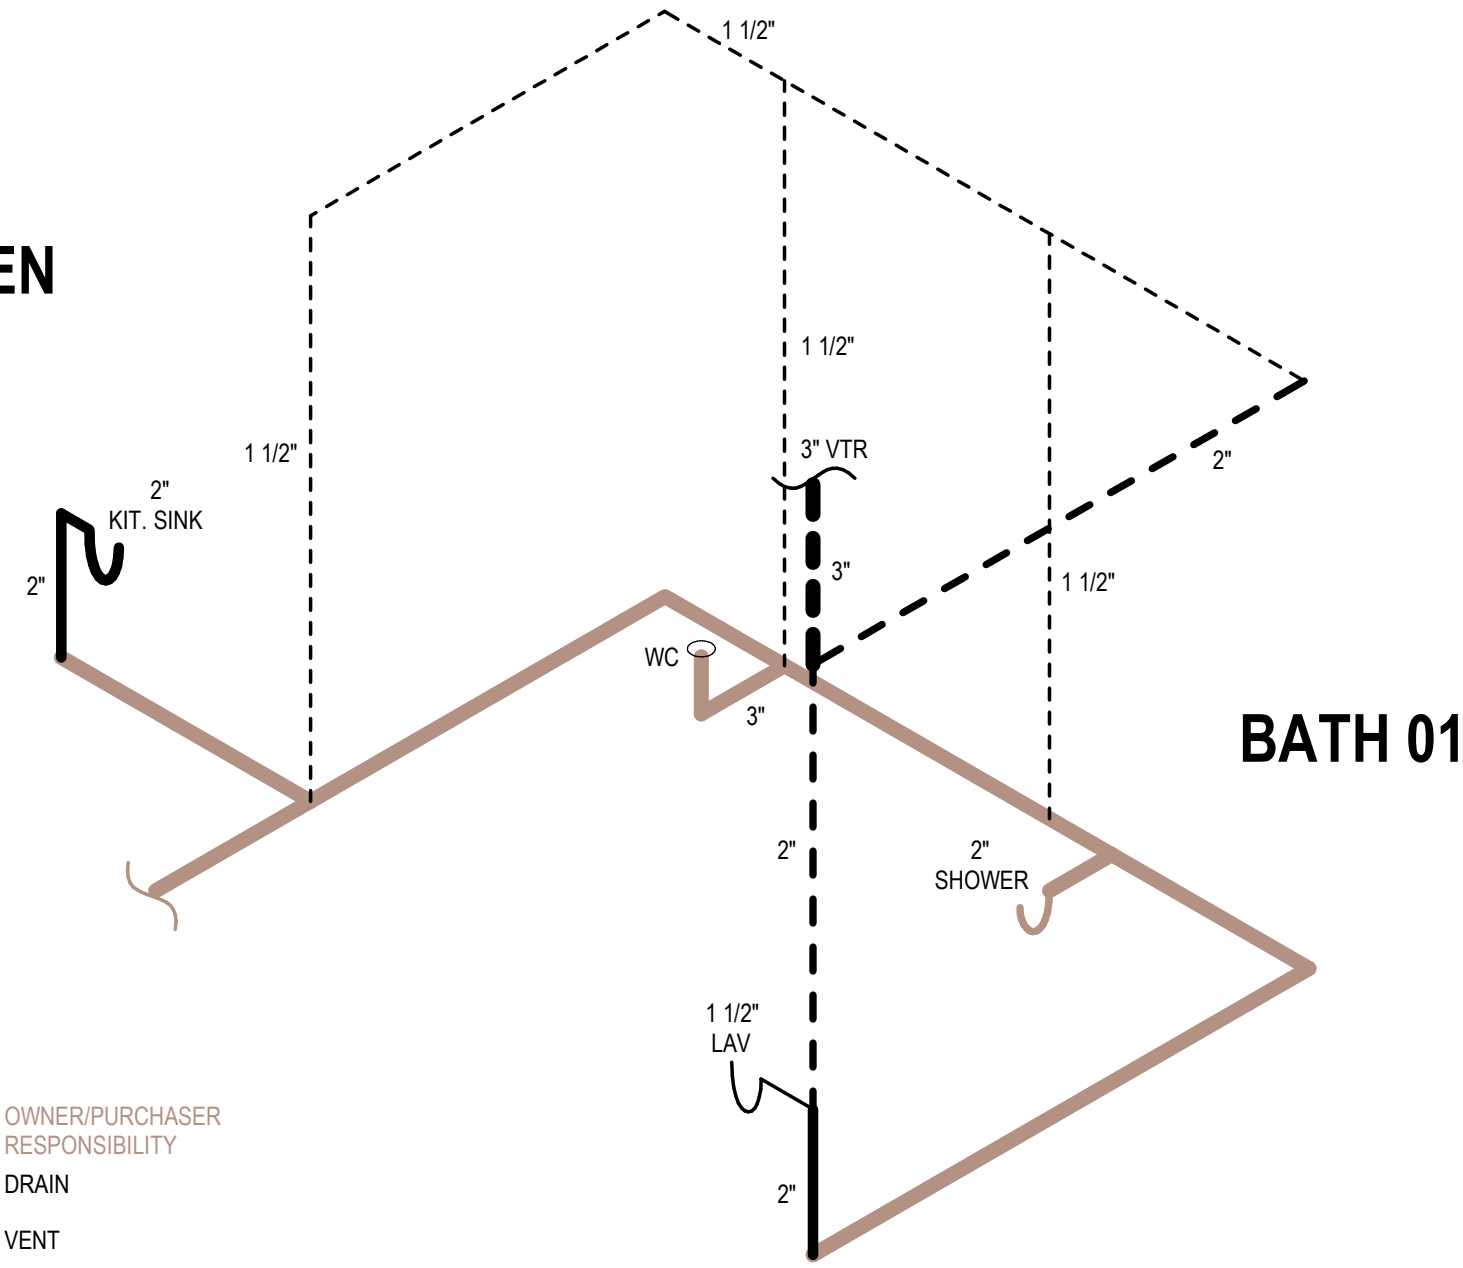

BATH 01

PLUMBING NOTES

- 1 SEE ALL GENERAL NOTES & DISCIPLINE NOTES LOCATED ON A001
- 2 MECHANICAL, ELECTRICAL AND PLUMBING SYSTEMS TO BE ENGINEERED BY RESIDENTIAL MODULAR BUILDING MANUFACTURER. ALL ENGINEERING SHOWN IS SCHEMATIC AND FOR REFERENCE ONLY. ALL SYSTEMS MUST MEET MANUFACTURER RECOMMENDATIONS, ALL APPLICABLE CODES AND AHJ REQUIREMENTS.

PRELIMINARY NOT FOR CONSTRUCTION

Not for permits, pricing or other official purposes. This document has not been completed or checked and is for general information or comment only.

A/E: FIRM
PRIME:
STANTEC
CHEYENNE, WY


DESIGNED:
JC
CADD:
BB/PS/AS
TECH. REVIEW:
LF
DATE:
06/18/2026

SUB SHEET NO.
P101D

TITLE OF SHEET
3BR ABA PLUMBING PLAN

YELLOWSTONE NATIONAL PARK

DRAWING NO.
101
198433
PMIS/PKG NO.
326141
SHEET
82 OF **94**

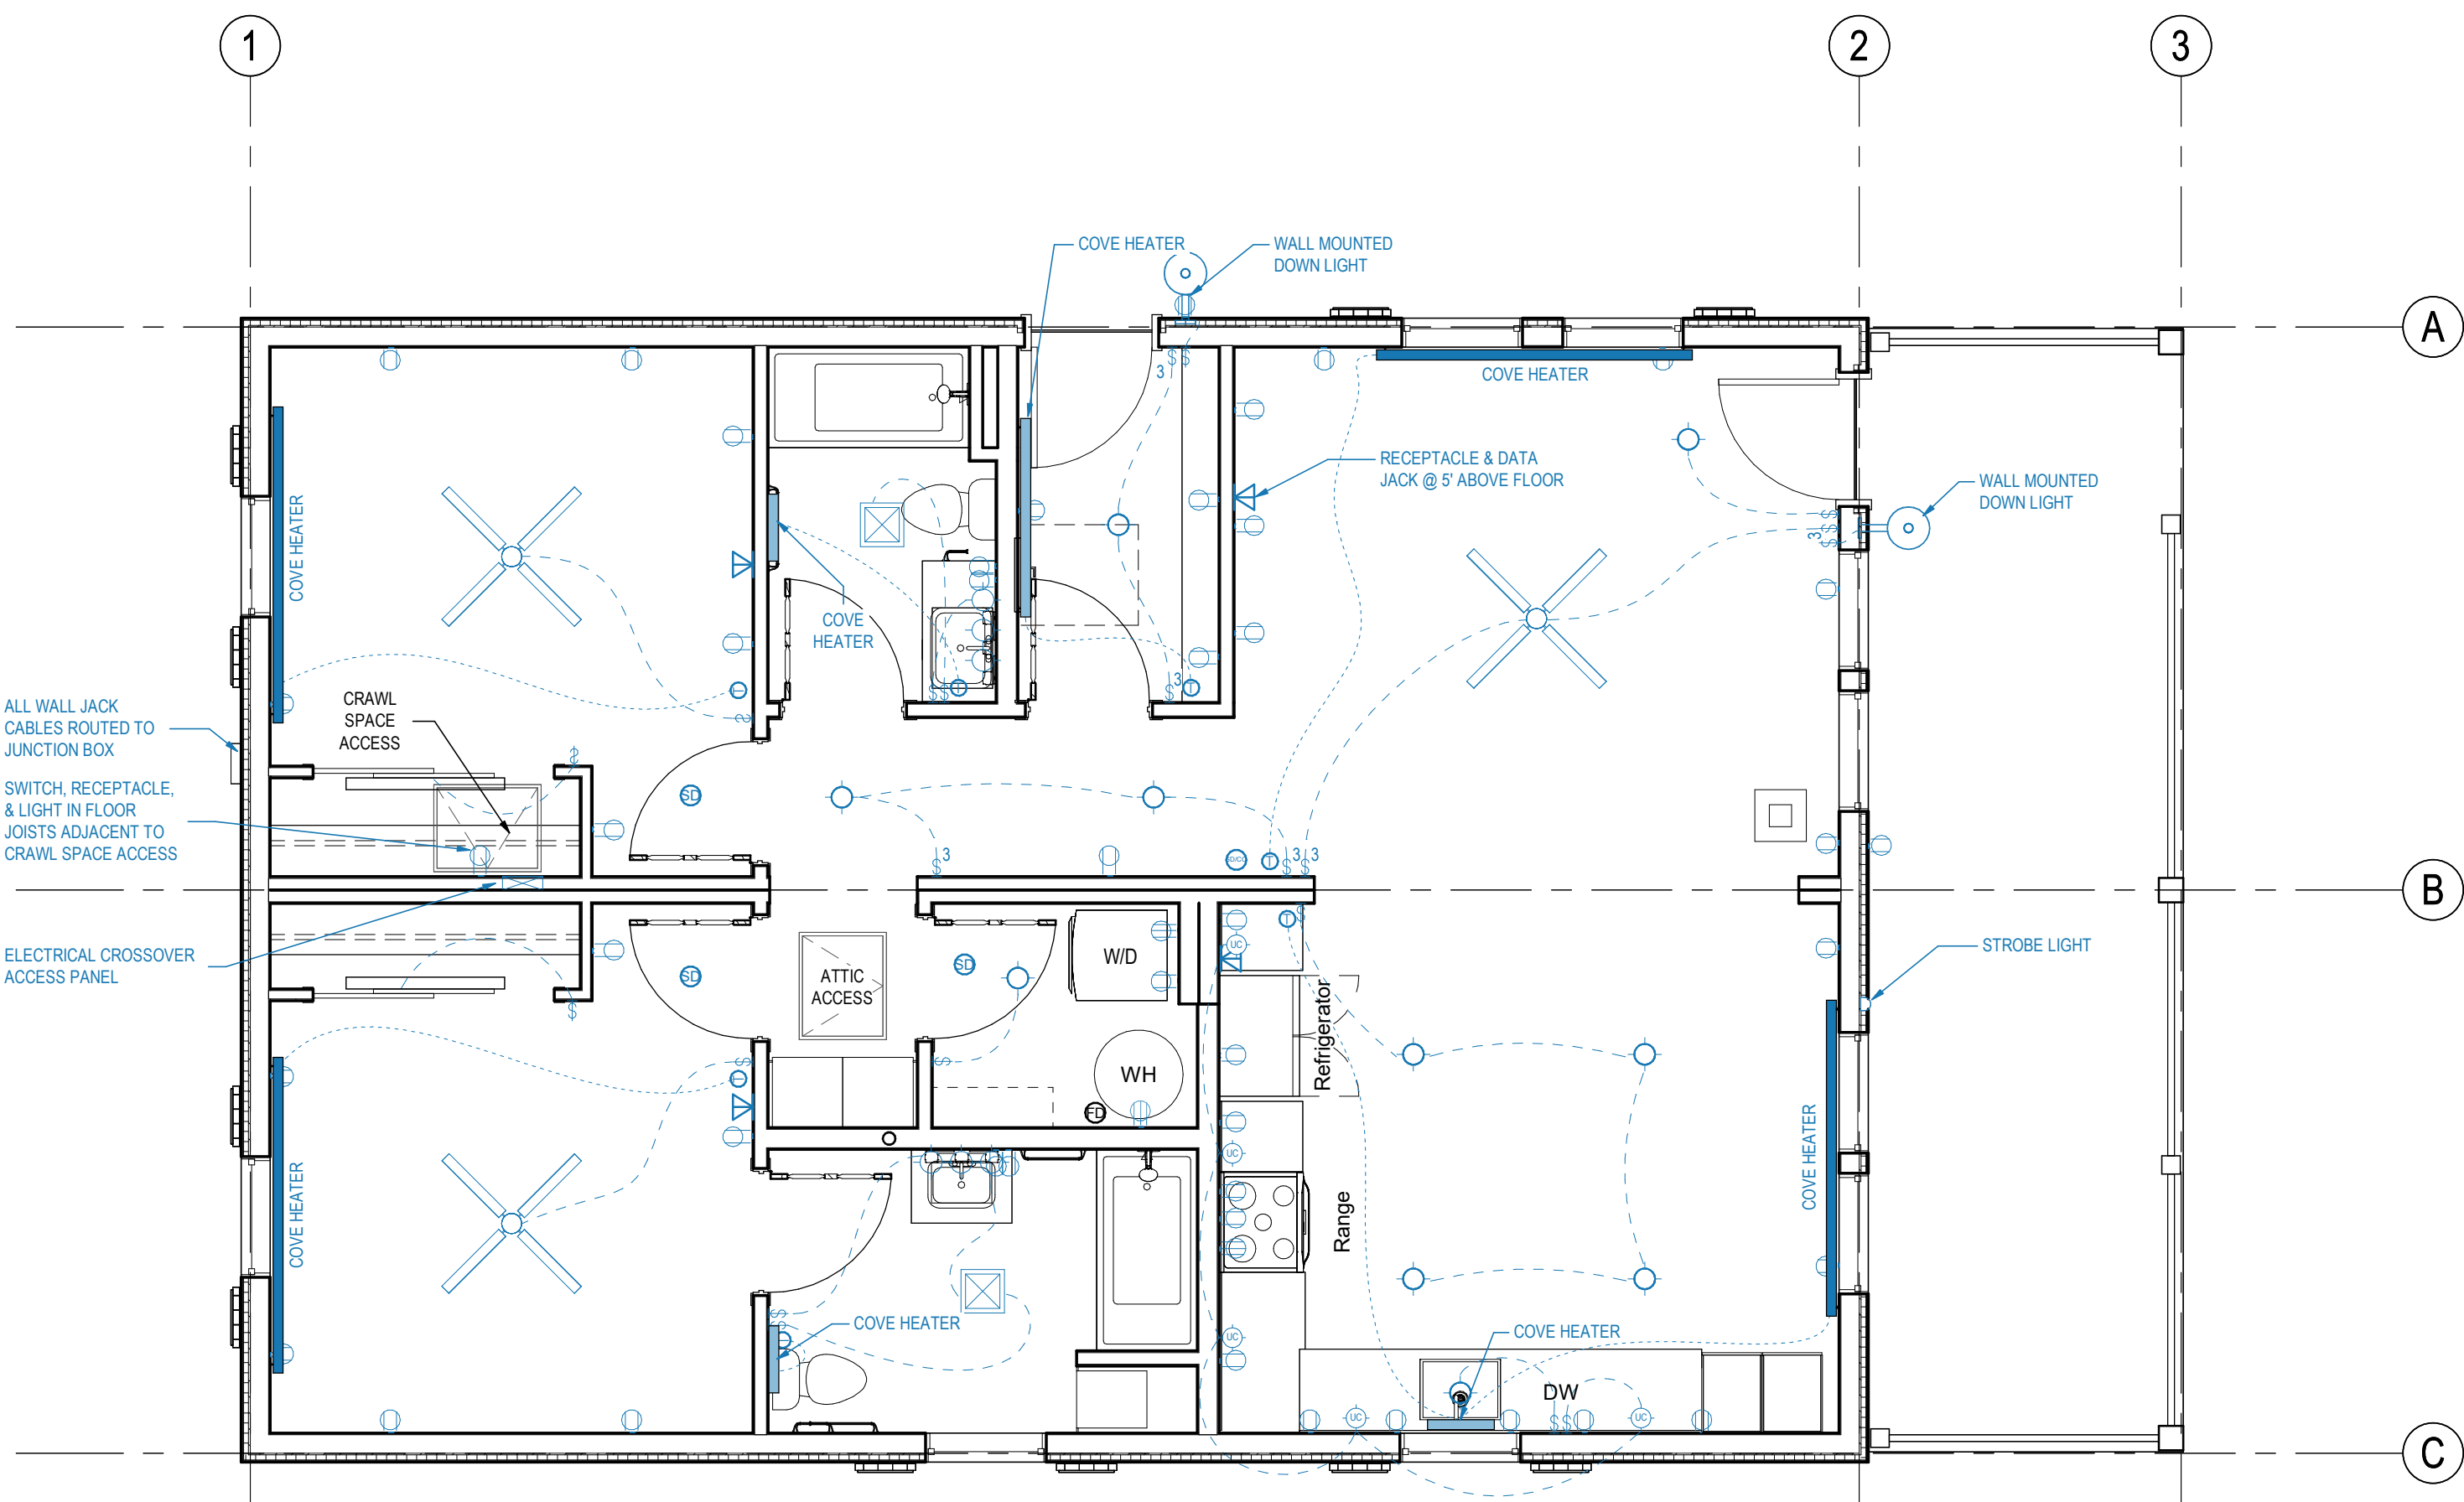

A1 ELECTRICAL PLAN
E101A 1/4" = 1'-0"

**PRELIMINARY
NOT FOR
CONSTRUCTION**
Not for permits, pricing or other official
purposes. This document has not been
completed or checked and is for general
information or comment only.

A/E: FIRM PRIME: STANTEC CHEYENNE, WY	DESIGNED: JC	SUB SHEET NO. E101A	TITLE OF SHEET 2BR ELECTRICAL PLAN YELLOWSTONE NATIONAL PARK	DRAWING NO. 101 198433 PMIS/PKG NO. 326141 SHEET 83 OF 94
	CADD: BB/PS/AS			
	TECH. REVIEW: LF			
	DATE: 06/18/2026			

A




Not for permits, pricing or other official purposes. This document has not been completed or checked and is for general information or comment only.

A/E: FIRM	DESIGNED: JC	SUB SHEET NO.	TITLE OF SHEET	DRAWING NO. 101
PRIME:	CADD:			198433
STANTEC CHEYENNE, WY	BB/PS/AS			PMIS/PKG NO. 326141A/326104
	TECH. REVIEW:			SHEET
	LF			84 OF 94
	DATE: 06/18/2026		YELLOWSTONE NATIONAL PARK	

C

B

A

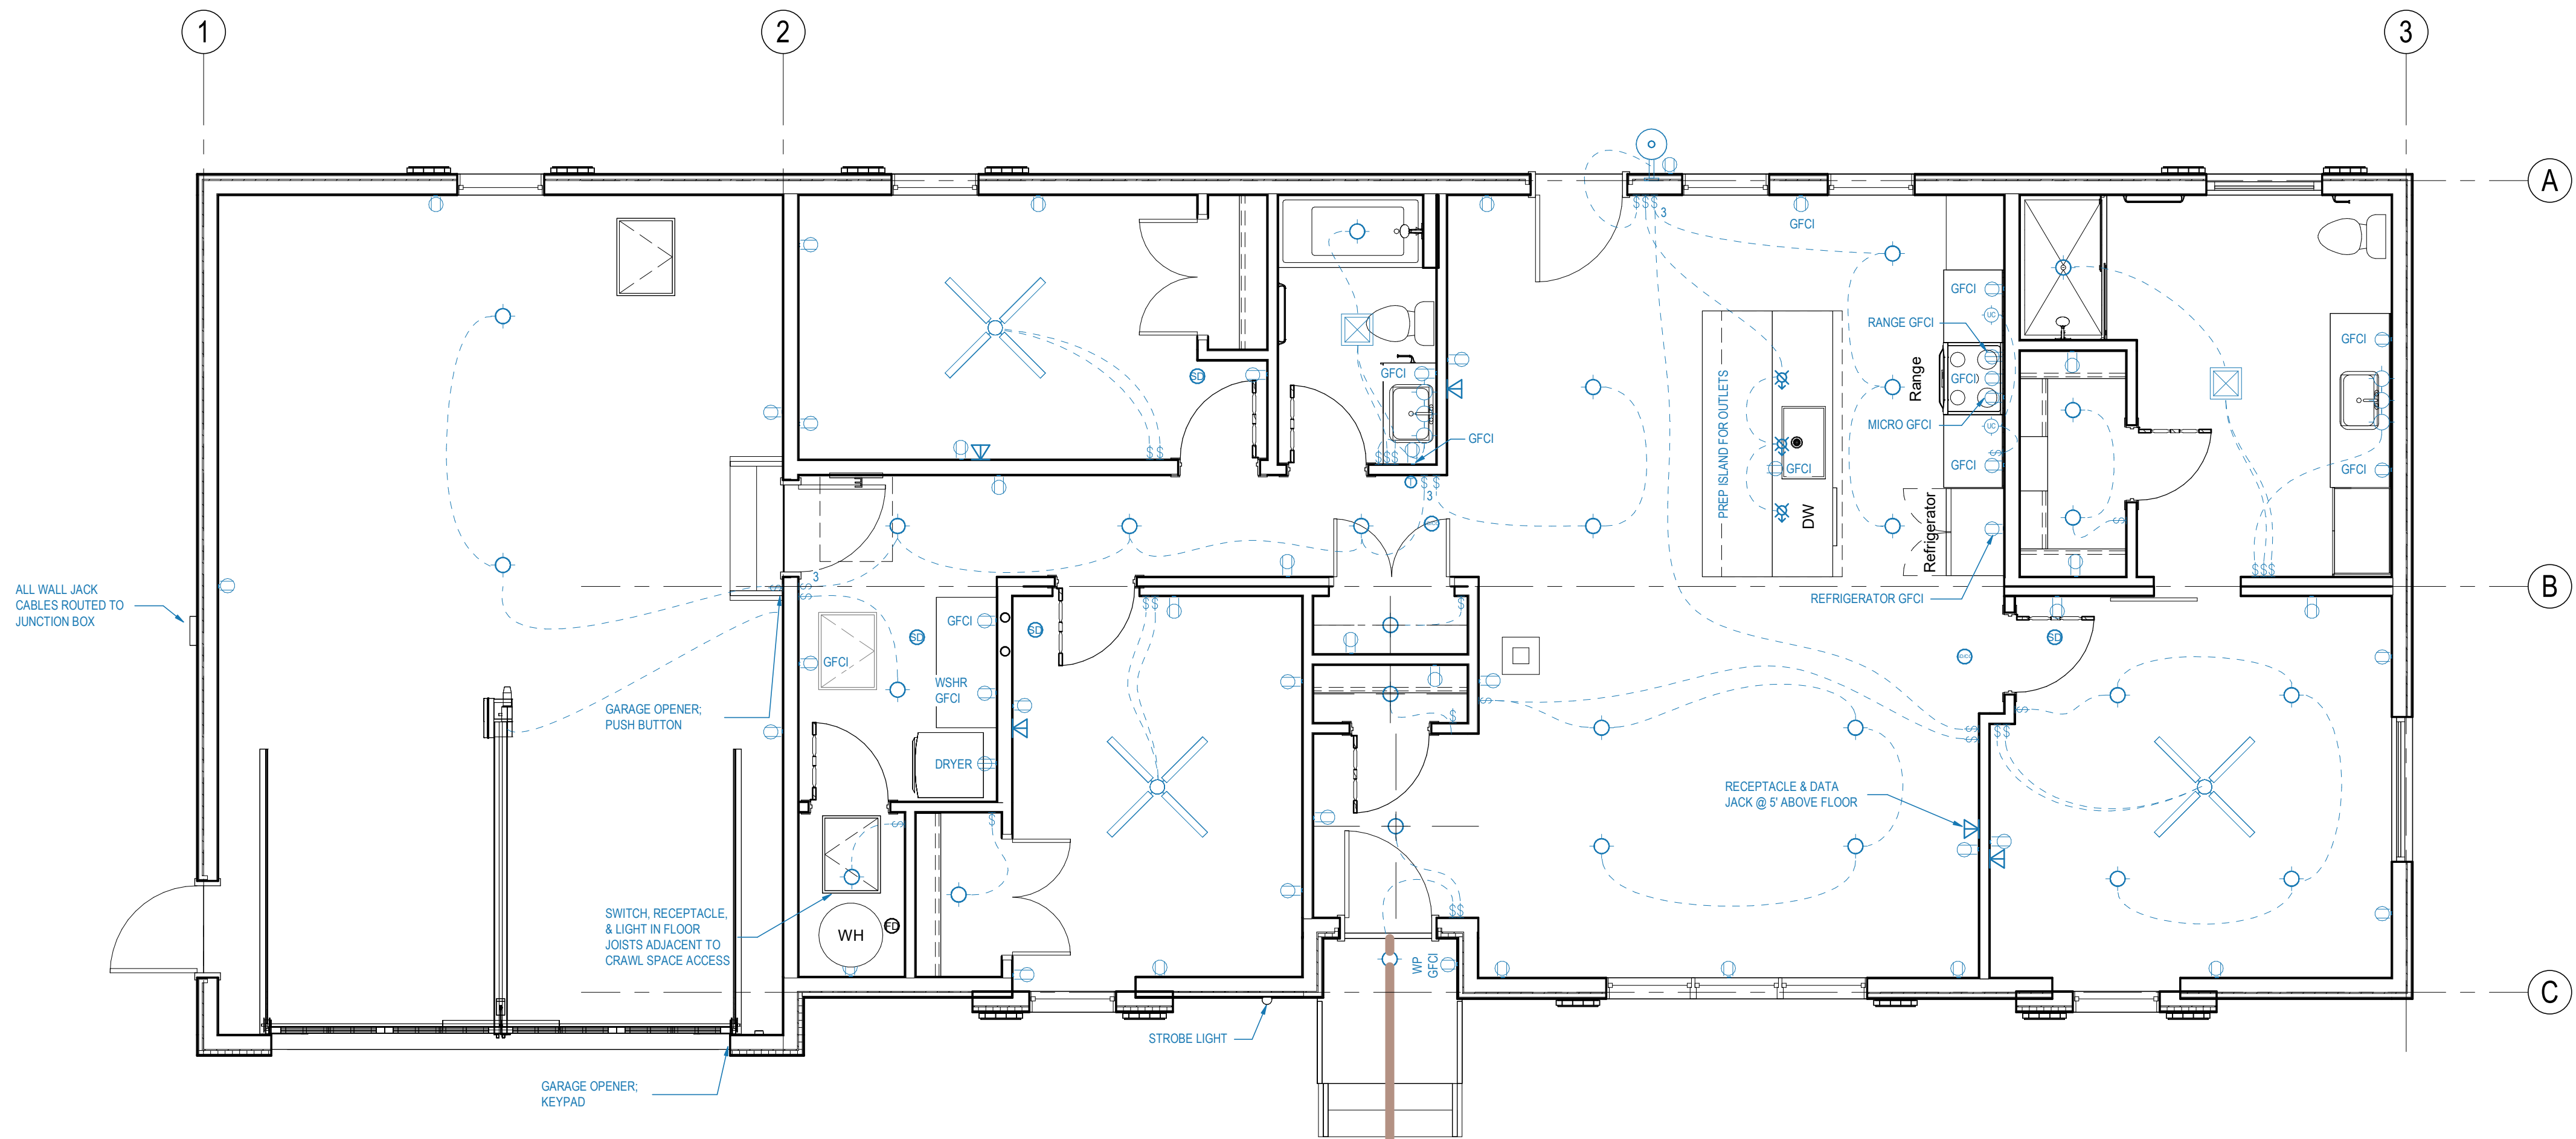

A1
E101C
ELECTRICAL PLAN
1/4" = 1'-0"

**PRELIMINARY
NOT FOR
CONSTRUCTION**
Not for permits, pricing or other official
purposes. This document has not been
completed or checked and is for general
information or comment only.

A/E: FIRM PRIME: STANTEC CHEYENNE, WY	DESIGNED: JC	SUB SHEET NO. E101C	TITLE OF SHEET 3BR ELECTRICAL PLAN YELLOWSTONE NATIONAL PARK	DRAWING NO. 101 198433
	CADD: BB/PS/AS			PMIS/PKG NO. 326141
	TECH. REVIEW: LF			SHEET
	DATE: 06/18/2026			85 OF 94