

ALL RENDERINGS FOR REFERENCE ONLY



KITCHEN - DAY



KITCHEN - EVENING

FILED: 4/17/2024 3:44:40 PM - PRINT: 4/17/2024 3:44:40 PM
ANSI: 2015-07-01 11:55:58 AM - 11:55:58 AM - 11:55:58 AM - 11:55:58 AM

**PRELIMINARY
NOT FOR
CONSTRUCTION**
Not for permits, pricing or other official
purposes. This document has not been
completed or checked and is for general
information or comment only.

A/E: FIRM PRIME: STANTEC CHEYENNE, WY	DESIGNED: JC	SUB SHEET NO. A901C	TITLE OF SHEET 3BR RENDERINGS 76 OF 94	DRAWING NO. 101 198433 PMIS/PKG NO. 326141
	CADD: BB/PS/AS			
	TECH. REVIEW: LF			SHEET
	DATE: 06/18/2026		YELLOWSTONE NATIONAL PARK	77 OF 94

ALL RENDERINGS FOR REFERENCE ONLY



KITCHEN - DAY



KITCHEN - EVENING

Plot Date: 4/17/2024 3:54:41 PM, Print Version: 202
Autodesk Docs/1185702678_VEL_MIS/526_sen1_185702678_3dpr_000.vr

**PRELIMINARY
NOT FOR
CONSTRUCTION**
Not for permits, pricing or other official
purposes. This document has not been
completed or checked and is for general
information or comment only.

A/E: FIRM PRIME: STANTEC CHEYENNE, WY	DESIGNED: JC	SUB SHEET NO. A901D	TITLE OF SHEET 3BR ABA RENDERINGS YELLOWSTONE NATIONAL PARK	DRAWING NO. 101 198433
	CADD: BB/PS/AS			PMIS/PKG NO. 326141
	TECH. REVIEW: LF			SHEET
	DATE: 06/18/2026			78 OF 94


PLUMBING NOTES

- 1 SEE ALL GENERAL NOTES & DISCIPLINE NOTES LOCATED ON A001
2 MECHANICAL, ELECTRICAL AND PLUMBING SYSTEMS TO BE ENGINEERED BY RESIDENTIAL MODULAR BUILDING MANUFACTURER. ALL ENGINEERING SHOWN IS SCHEMATIC AND FOR REFERENCE ONLY. ALL SYSTEMS MUST MEET MANUFACTURER RECOMMENDATIONS, ALL APPLICABLE CODES AND AHJ REQUIREMENTS.

***THIS PLUMBING LAYOUT IS PROVIDED FOR REFERENCE AND COORDINATION PURPOSES ONLY. FINAL DESIGN, SIZING, AND ROUTING OF PLUMBING SYSTEMS SHALL BE COMPLETED BY MODULAR HOUSING MANUFACTURER.

BATH 01


OWNER/PURCHASER RESPONSIBILITY
DRAIN
VENT

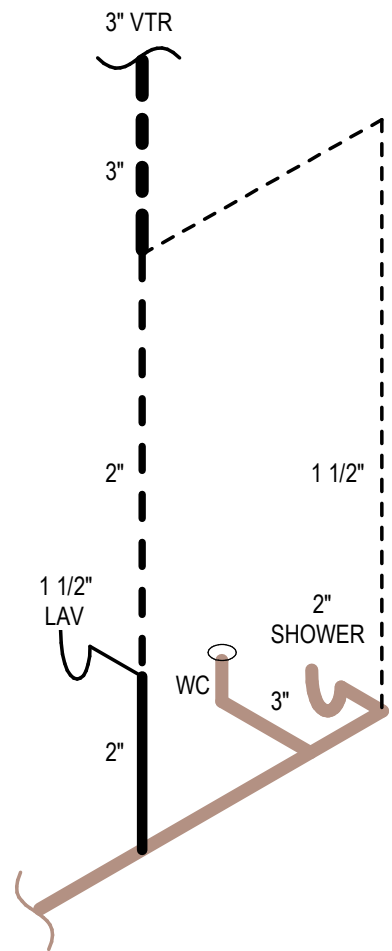


***THIS PLUMBING LAYOUT IS PROVIDED FOR REFERENCE AND COORDINATION PURPOSES ONLY. FINAL DESIGN, SIZING, AND ROUTING OF PLUMBING SYSTEMS SHALL BE COMPLETED BY MODULAR HOUSING MANUFACTURER.

BATH 02

OWNER/PURCHASER RESPONSIBILITY
DRAIN
VENT

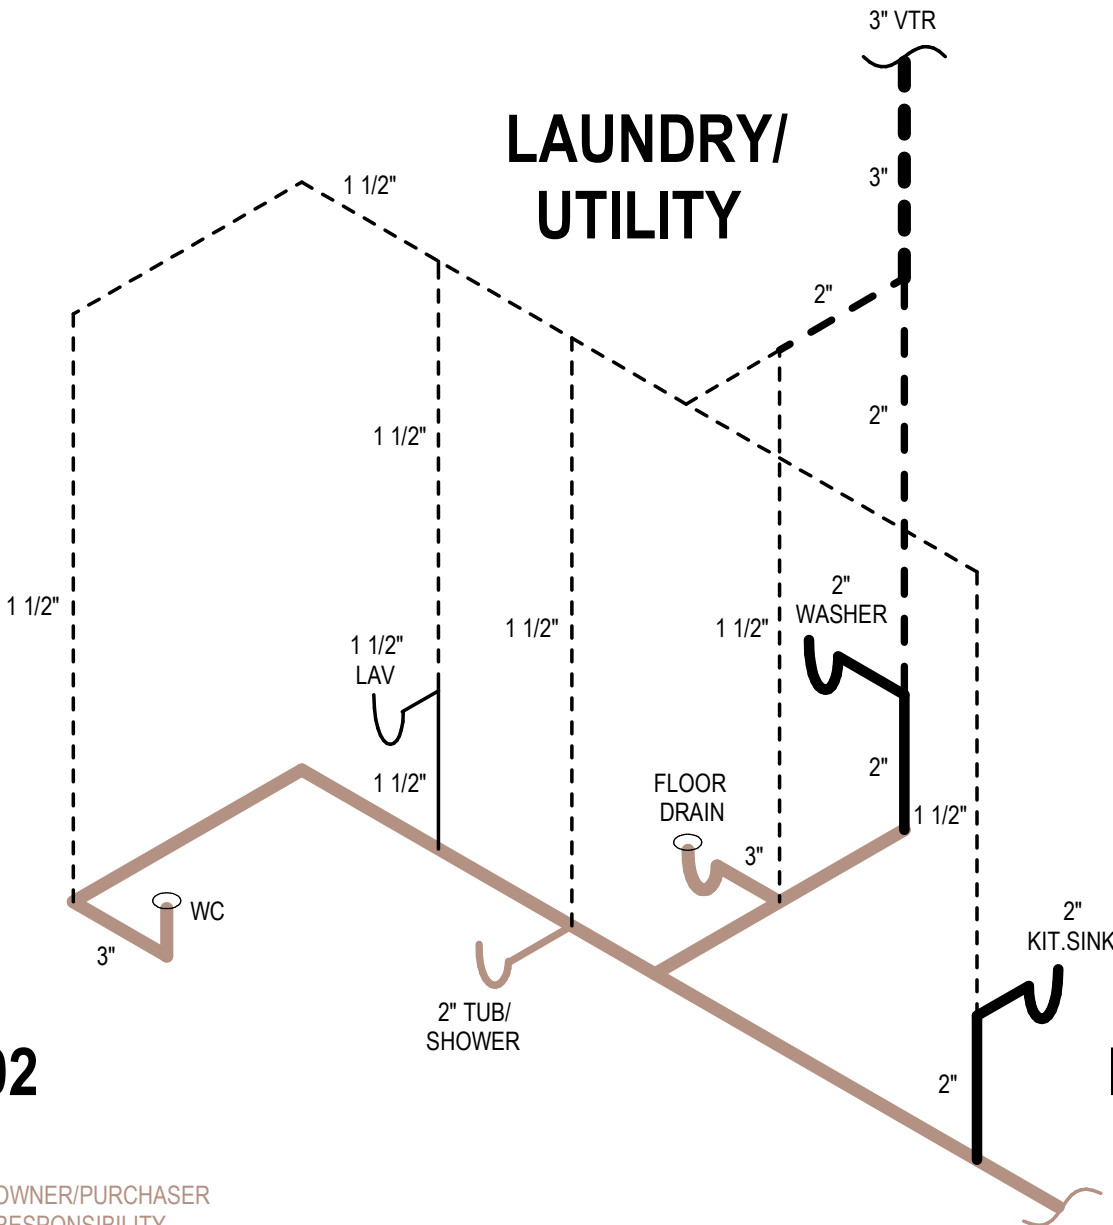

PROVIDE FREEZE-PROTECTED HOSE BIBB. LOCATION MAY VARY. COORDINATE WITH MODULAR BUILDINGS MANUFACTURER. RE: SHOP DRAWINGS.

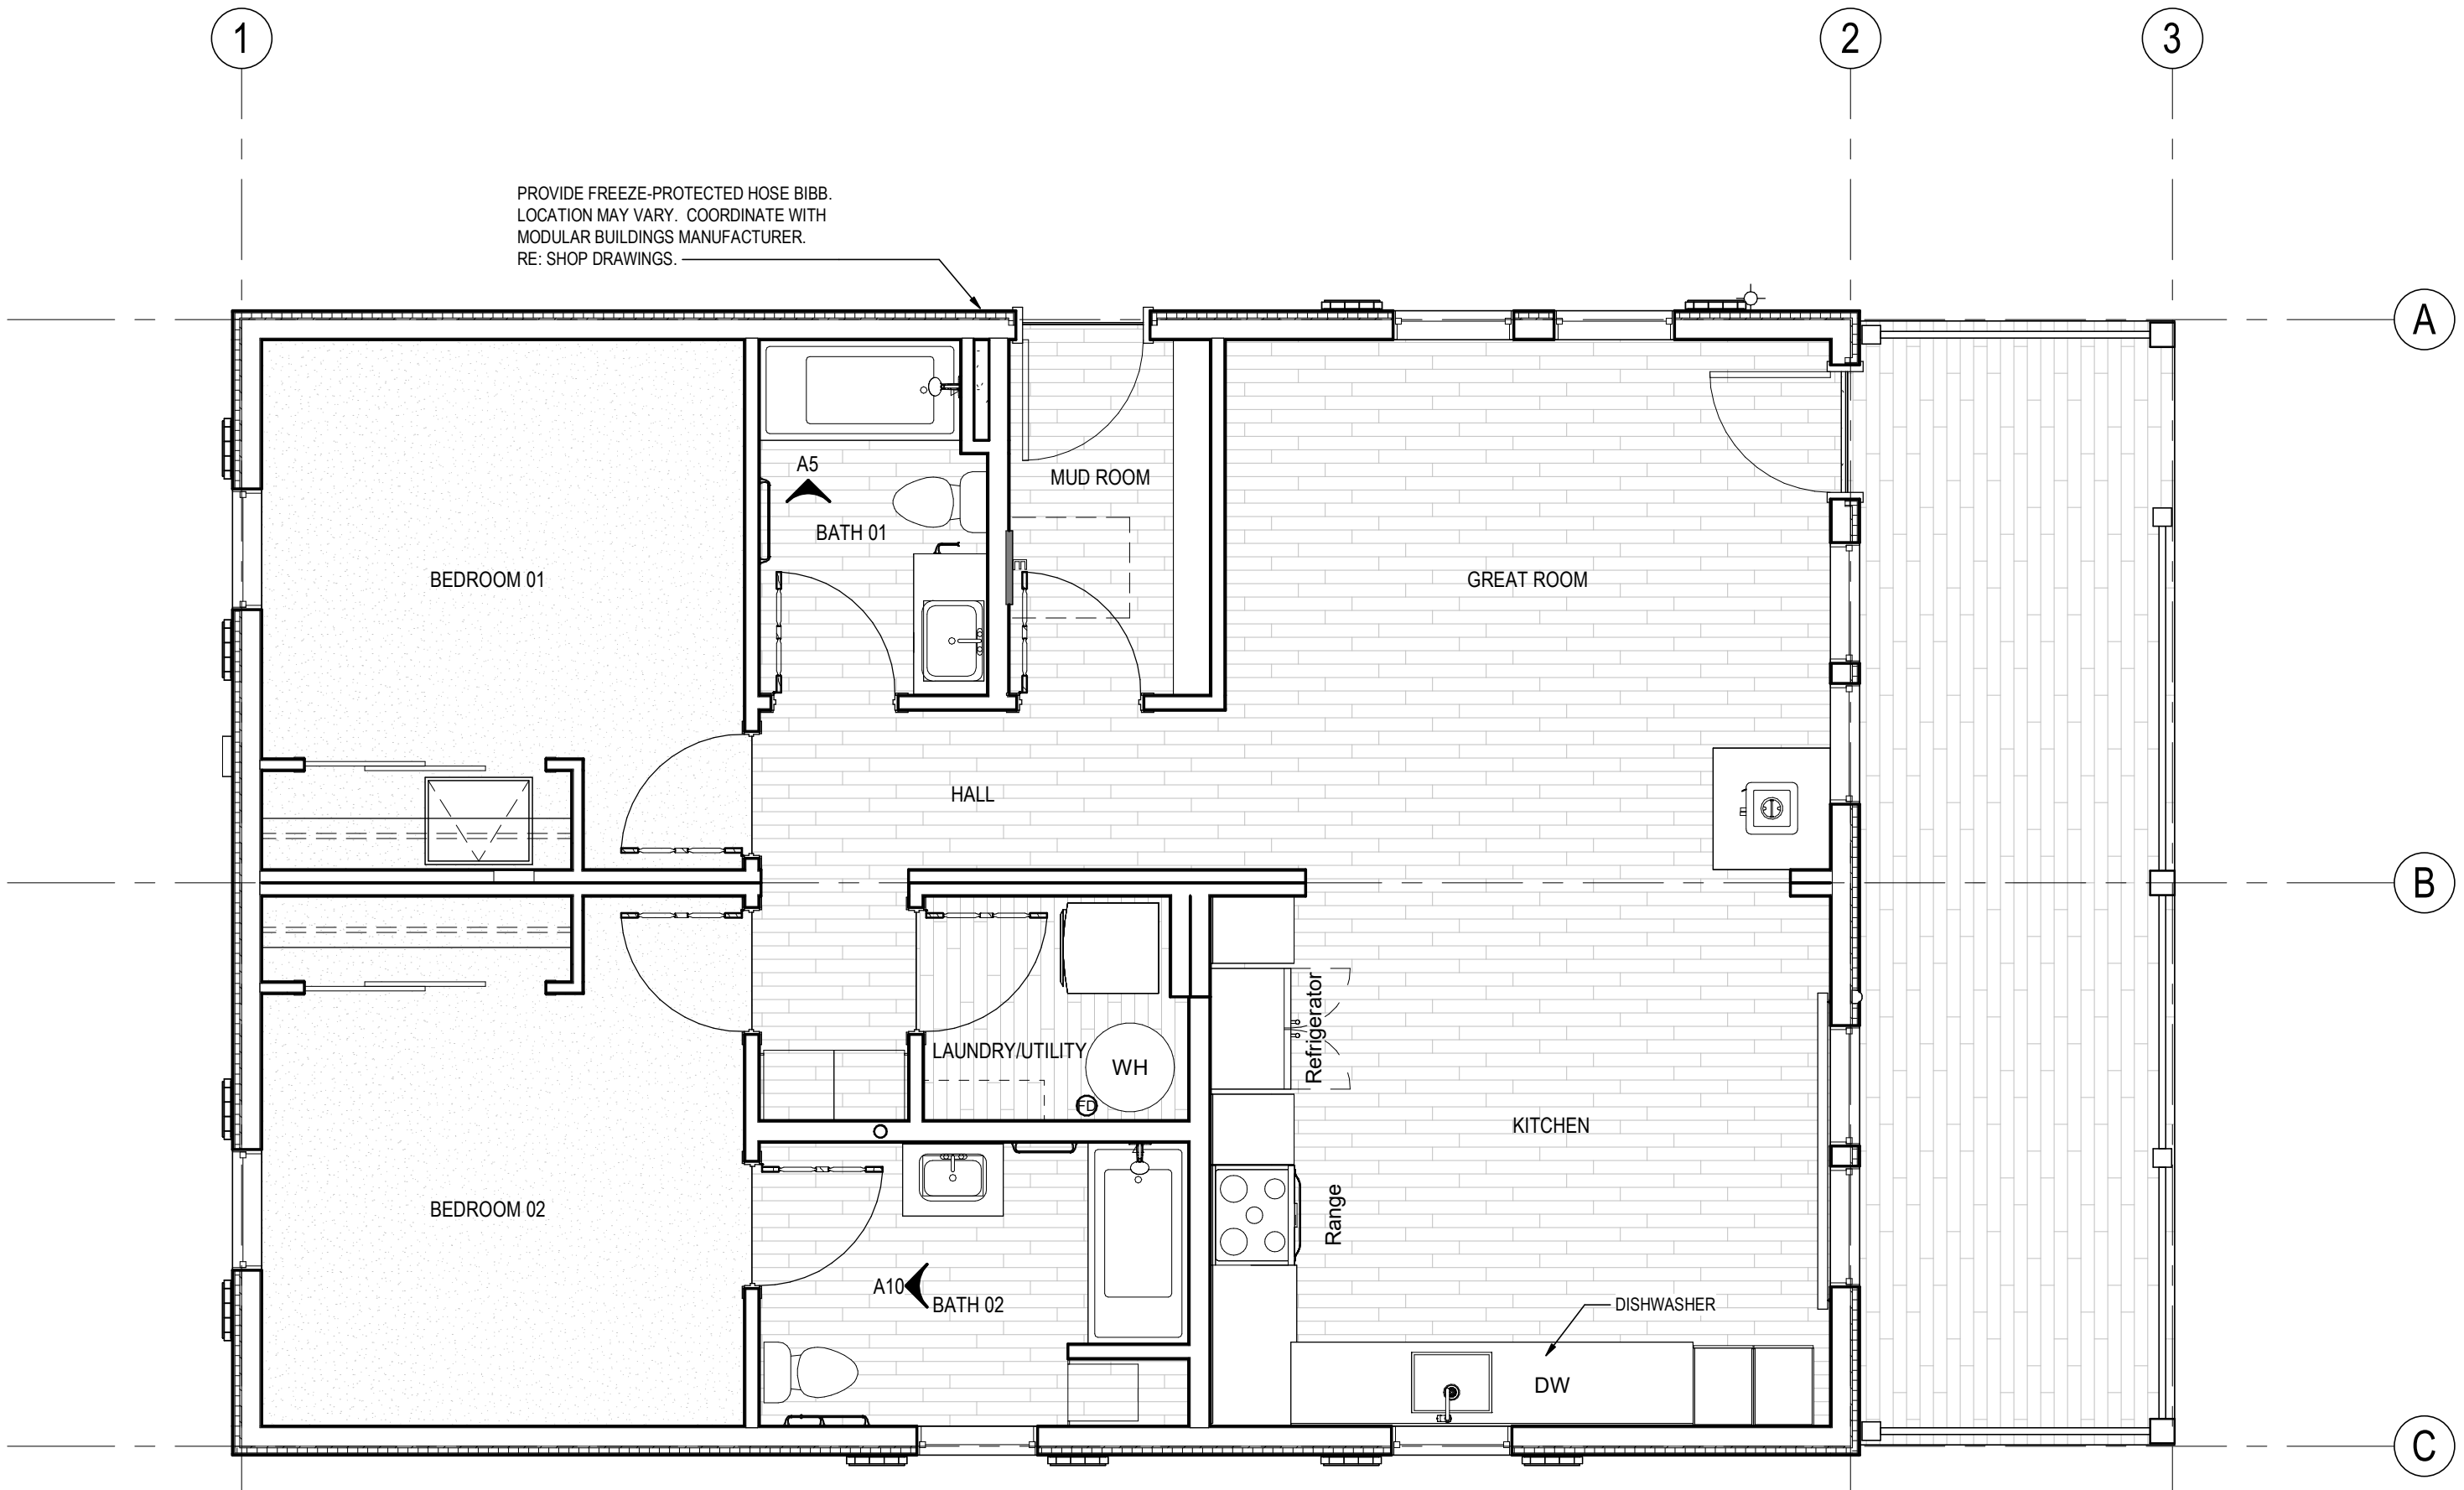

A1 LEVEL 01
P101A 1/4" = 1'-0"

PRELIMINARY
NOT FOR
CONSTRUCTION

Not for permits, pricing or other official purposes. This document has not been completed or checked and is for general information or comment only.

A/E: FIRM
PRIME:
STANTEC
CHEYENNE, WY

DESIGNED:
JC
CADD:
BB/PS/AS
TECH. REVIEW:
LF
DATE:
06/18/2026

SUB SHEET NO.
P101A


TITLE OF SHEET
2BR PLUMBING PLAN

YELLOWSTONE NATIONAL PARK


DRAWING NO.
101
198433
PMIS/PKG NO.
326141
SHEET
79 OF **94**

1	SEE ALL GENERAL NOTES & DISCIPLINE NOTES LOCATED ON A001
2	MECHANICAL, ELECTRICAL AND PLUMBING SYSTEMS TO BE ENGINEERED BY RESIDENTIAL MODULAR BUILDING MANUFACTURER. ALL ENGINEERING SHOWN IS SCHEMATIC AND FOR REFERENCE ONLY. ALL SYSTEMS MUST MEET MANUFACTURER RECOMMENDATIONS, ALL APPLICABLE CODES AND AHJ REQUIREMENTS.

***THIS PLUMBING LAYOUT IS PROVIDED FOR REFERENCE AND COORDINATION PURPOSES ONLY.
FINAL DESIGN, SIZING, AND ROUTING OF PLUMBING SYSTEMS SHALL BE COMPLETED BY
MODULAR HOUSING MANUFACTURER.

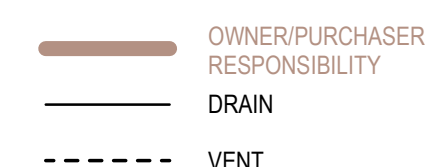

PROVIDE ACCESSIBLE FREEZE-PROTECTED HOSE BIBB. LOCATION MAY VARY. COORDINATE WITH MODULAR BUILDINGS MANUFACTURER. RE: SHOP DRAWINGS. —

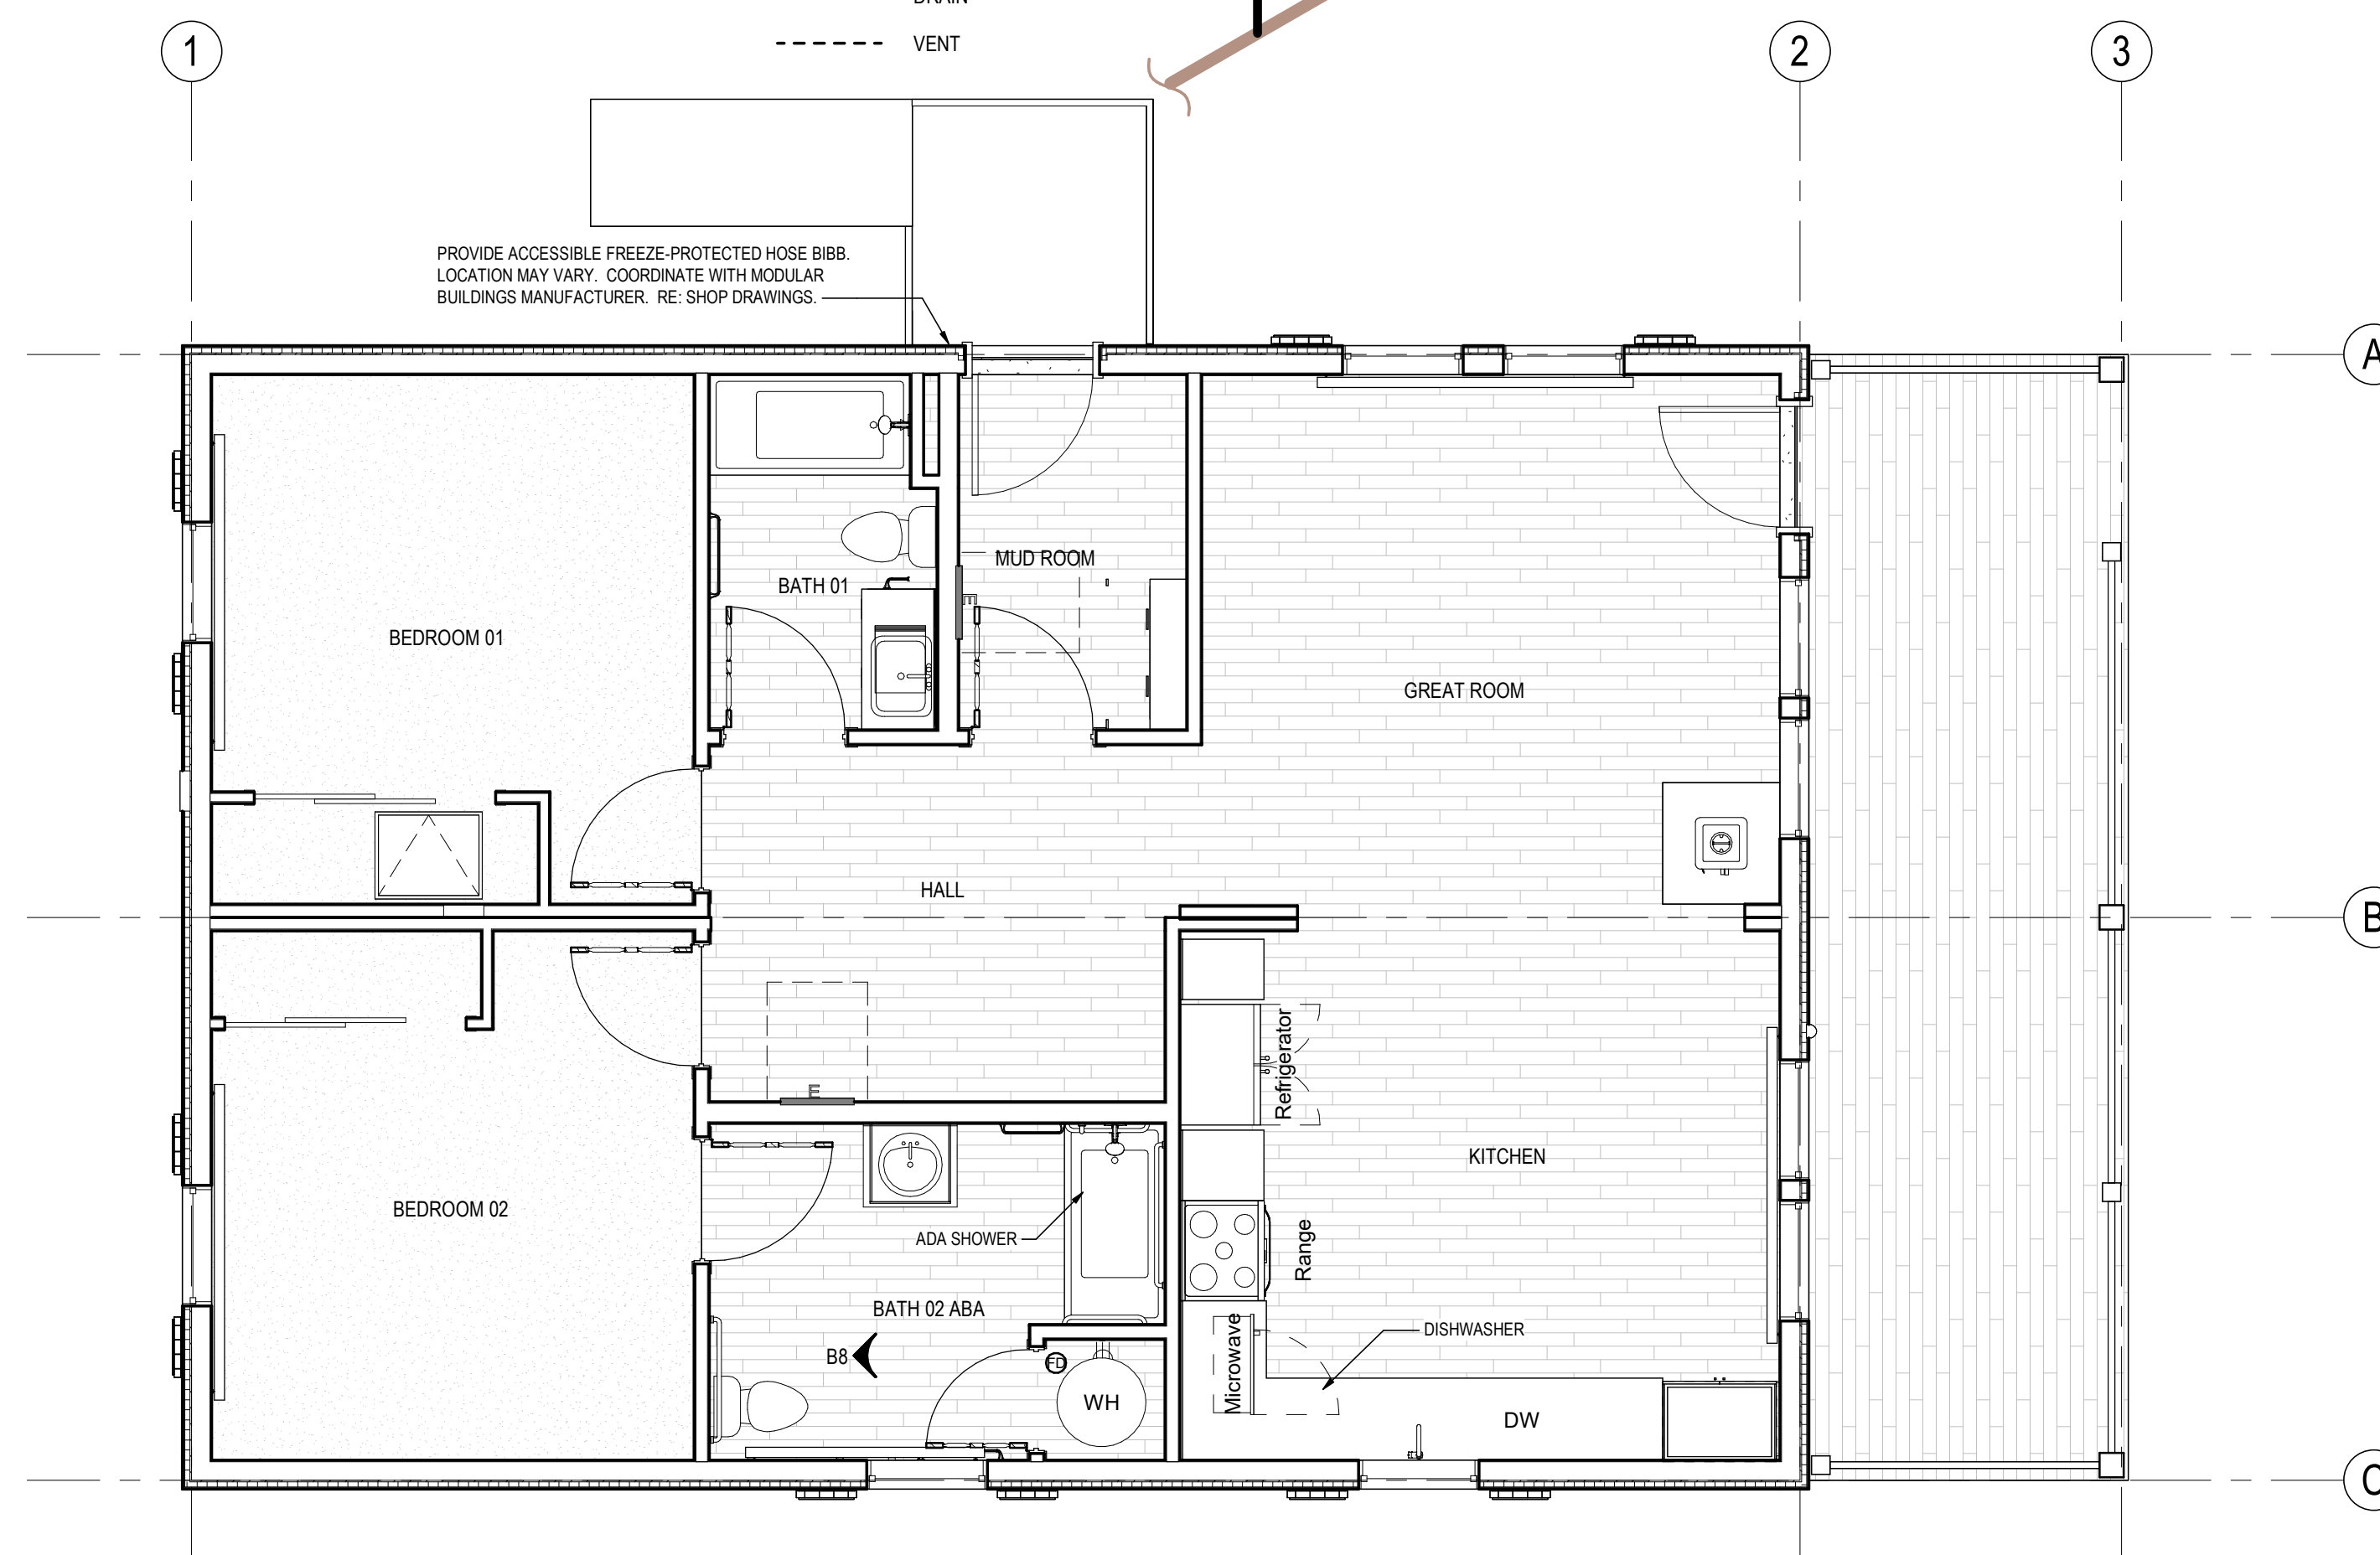

**PRELIMINARY
NOT FOR
CONSTRUCTION**

Not for permits, pricing or other official purposes. This document has not been completed or checked and is for general information or comment only.

DESIGNED:	JC
CADD:	BB/PS/AS
TECH. REVIEW:	LF
DATE:	06/18/2020

TITLE OF SHEET

2BR ABA PLUMBING PLAN

YELLOWSTONE NATIONAL PARK

DRAWING NO. 101 198433
PMIS/PKG NO. 326141A/326104
SHEET 80 OF 94

PLG DATE: 4/17/2024 3:44:40 PM, RUN DATE: 05/01/2024
ANSWER: D:\2024\18570708\TEL\18570708.dwg, 18570708.dwg

A

B

C

***THIS PLUMBING LAYOUT IS PROVIDED FOR REFERENCE AND COORDINATION PURPOSES ONLY.
FINAL DESIGN, SIZING, AND ROUTING OF PLUMBING SYSTEMS SHALL BE COMPLETED BY
MODULAR HOUSING MANUFACTURER.


***THIS PLUMBING LAYOUT IS PROVIDED FOR REFERENCE AND COORDINATION PURPOSES ONLY.
FINAL DESIGN, SIZING, AND ROUTING OF PLUMBING SYSTEMS SHALL BE COMPLETED BY
MODULAR HOUSING MANUFACTURER.

PLUMBING NOTES

- 1 SEE ALL GENERAL NOTES & DISCIPLINE NOTES LOCATED ON A001
- 2 MECHANICAL, ELECTRICAL AND PLUMBING SYSTEMS TO BE ENGINEERED BY RESIDENTIAL MODULAR BUILDING MANUFACTURER. ALL ENGINEERING SHOWN IS SCHEMATIC AND FOR REFERENCE ONLY. ALL SYSTEMS MUST MEET MANUFACTURER RECOMMENDATIONS AND ALL APPLICABLE CODES AND AHJ REQUIREMENTS.

LAUNDRY

OWNER/PURCHASER
RESPONSIBILITY
DRAIN
VENT

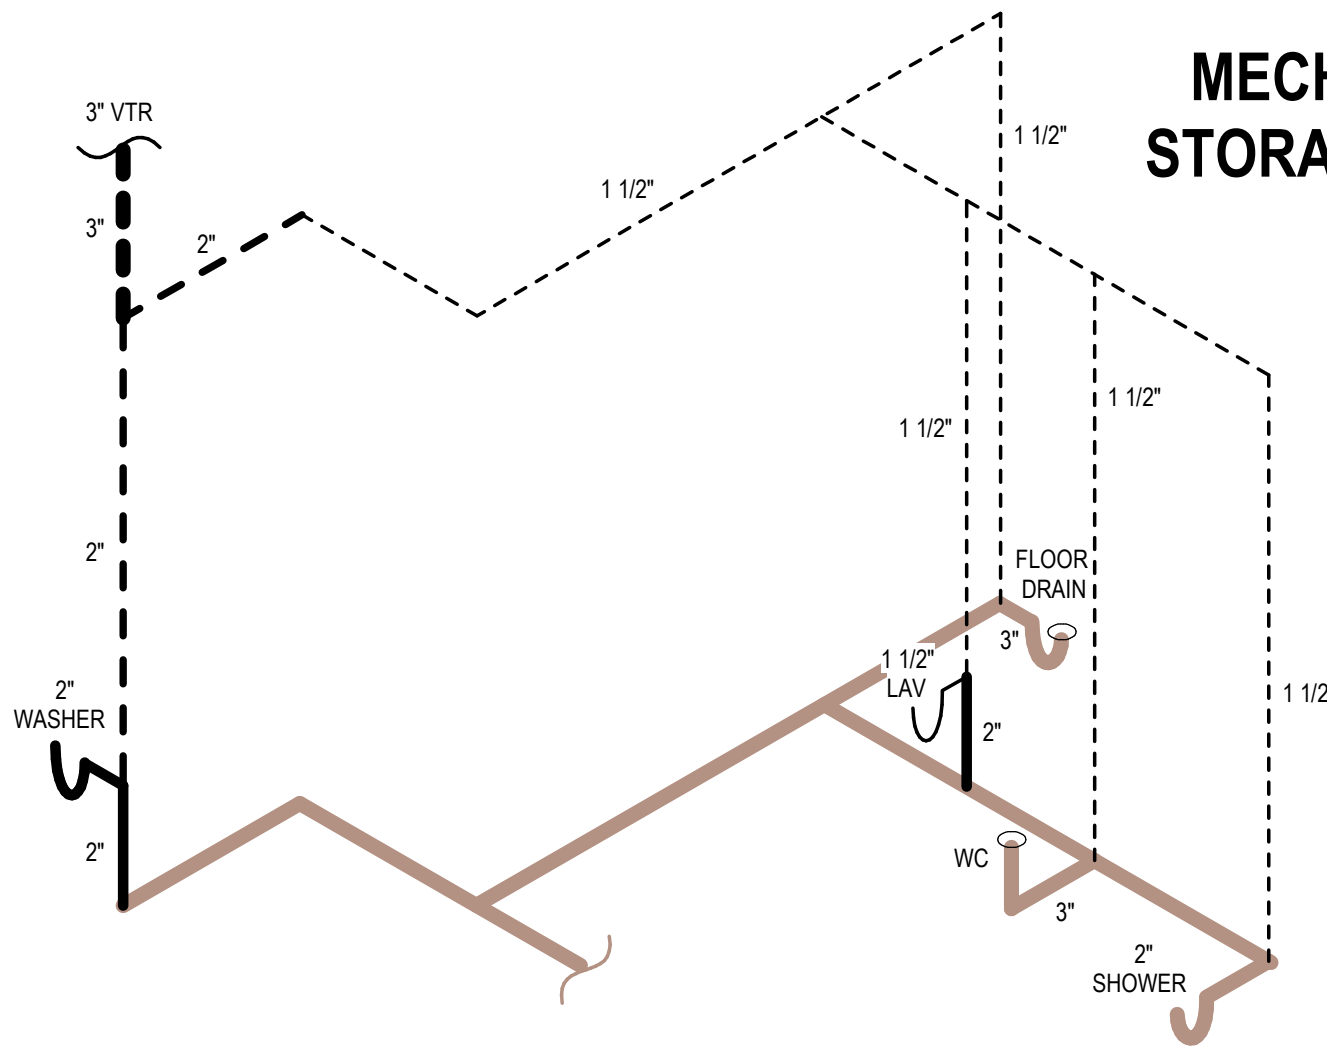


BATH 02


MECH/
STORAGE

KITCHEN

OWNER/PURCHASER
RESPONSIBILITY
DRAIN
VENT

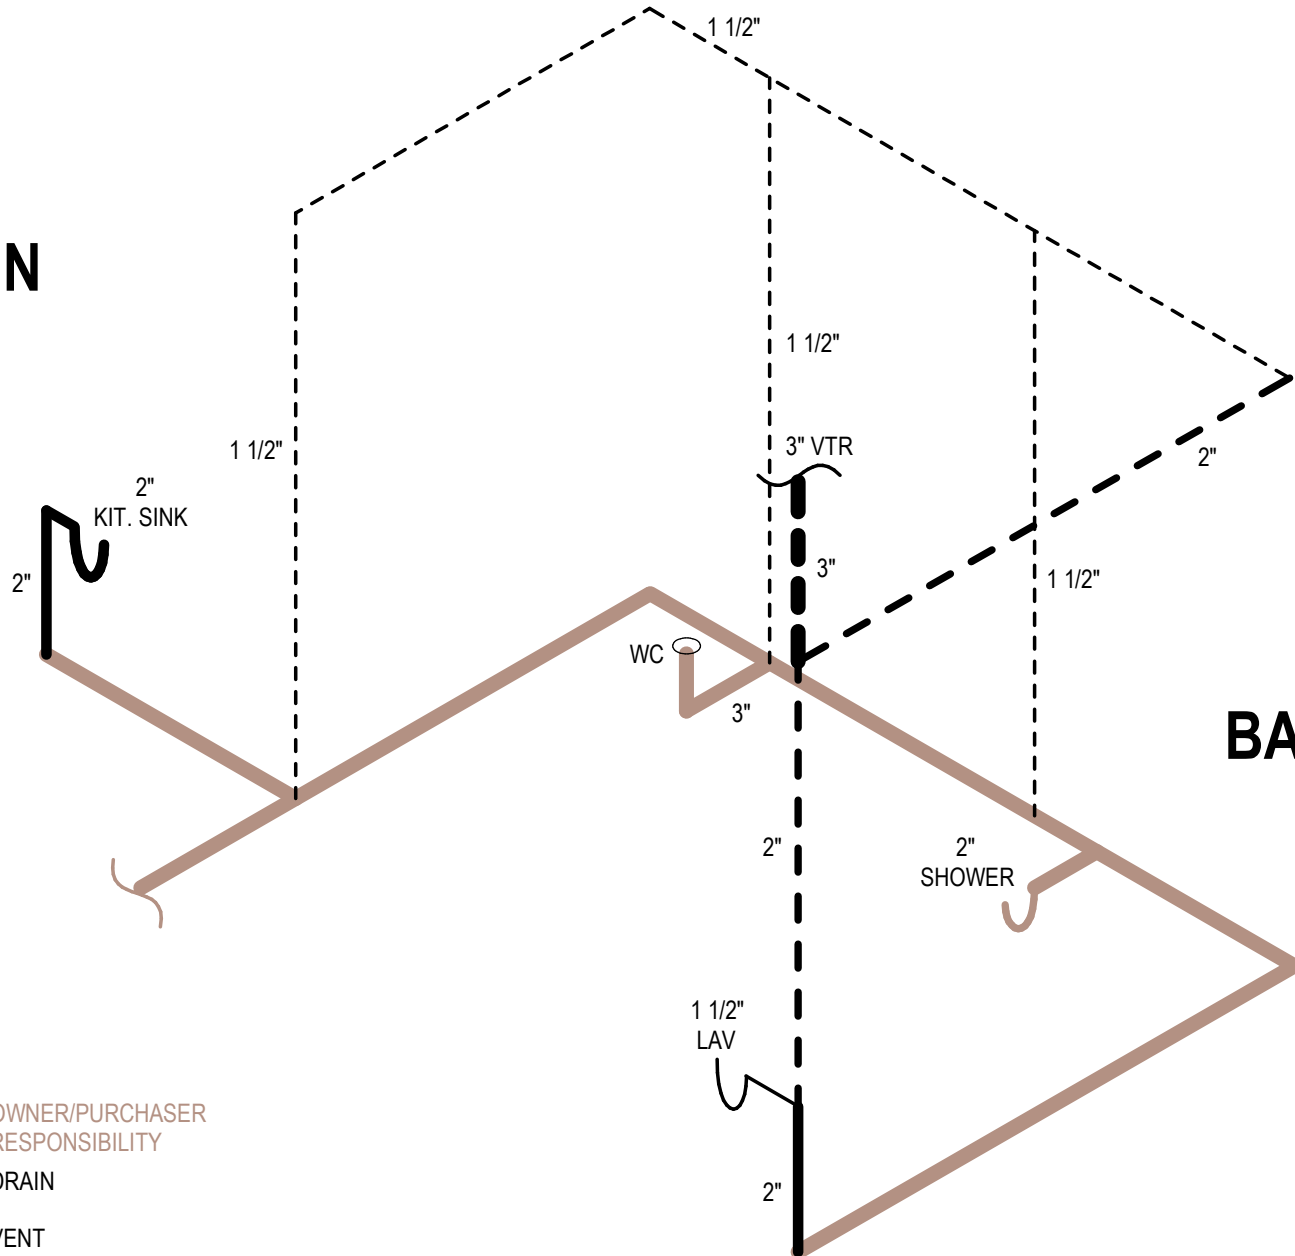

BATH 01

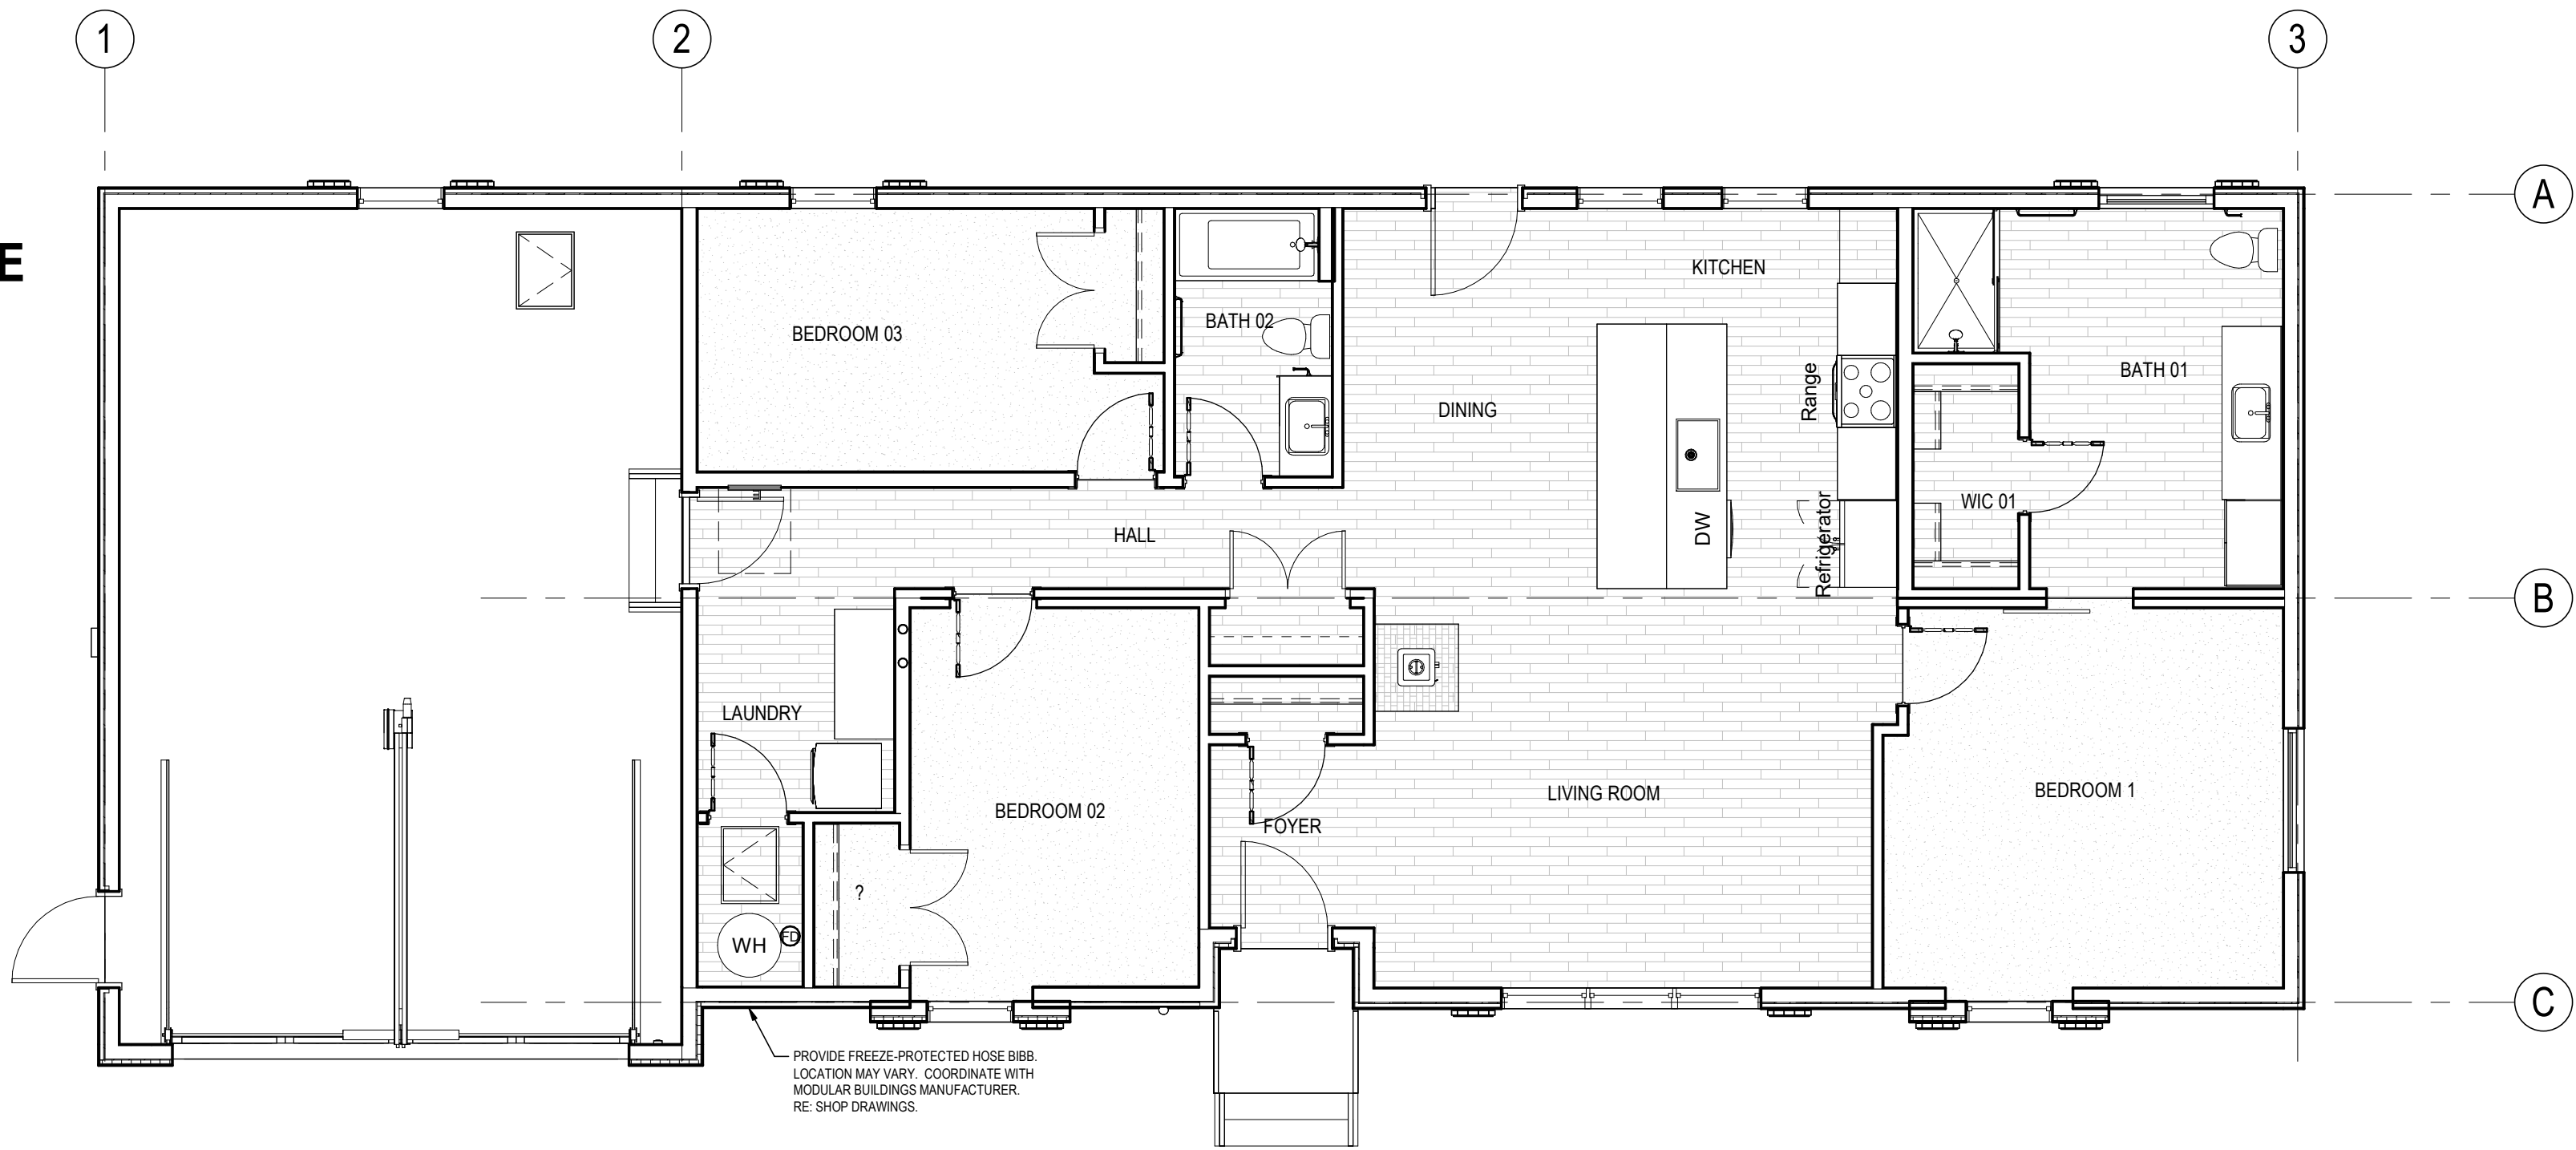

1A
P101C

LEVEL 01 PLUMBING PLAN

3/16" = 1'-0"

PRELIMINARY
NOT FOR
CONSTRUCTION

Not for permits, pricing or other official purposes. This document has not been completed or checked and is for general information or comment only.

A/E: FIRM
PRIME:
STANTEC
CHEYENNE, WY

DESIGNED:
JC
CADD:
BB/PS/AS
TECH. REVIEW:
LF
DATE:
06/18/2026

SUB SHEET NO.

P101C

TITLE OF SHEET

3BR PLUMBING PLAN

YELLOWSTONE NATIONAL PARK

DRAWING NO.
101
198433
PMIS/PKG NO.
326141
SHEET
81 OF **94**